




01
FIRST FLOOR PLAN - EXISTING
1/4" = 1'-0"

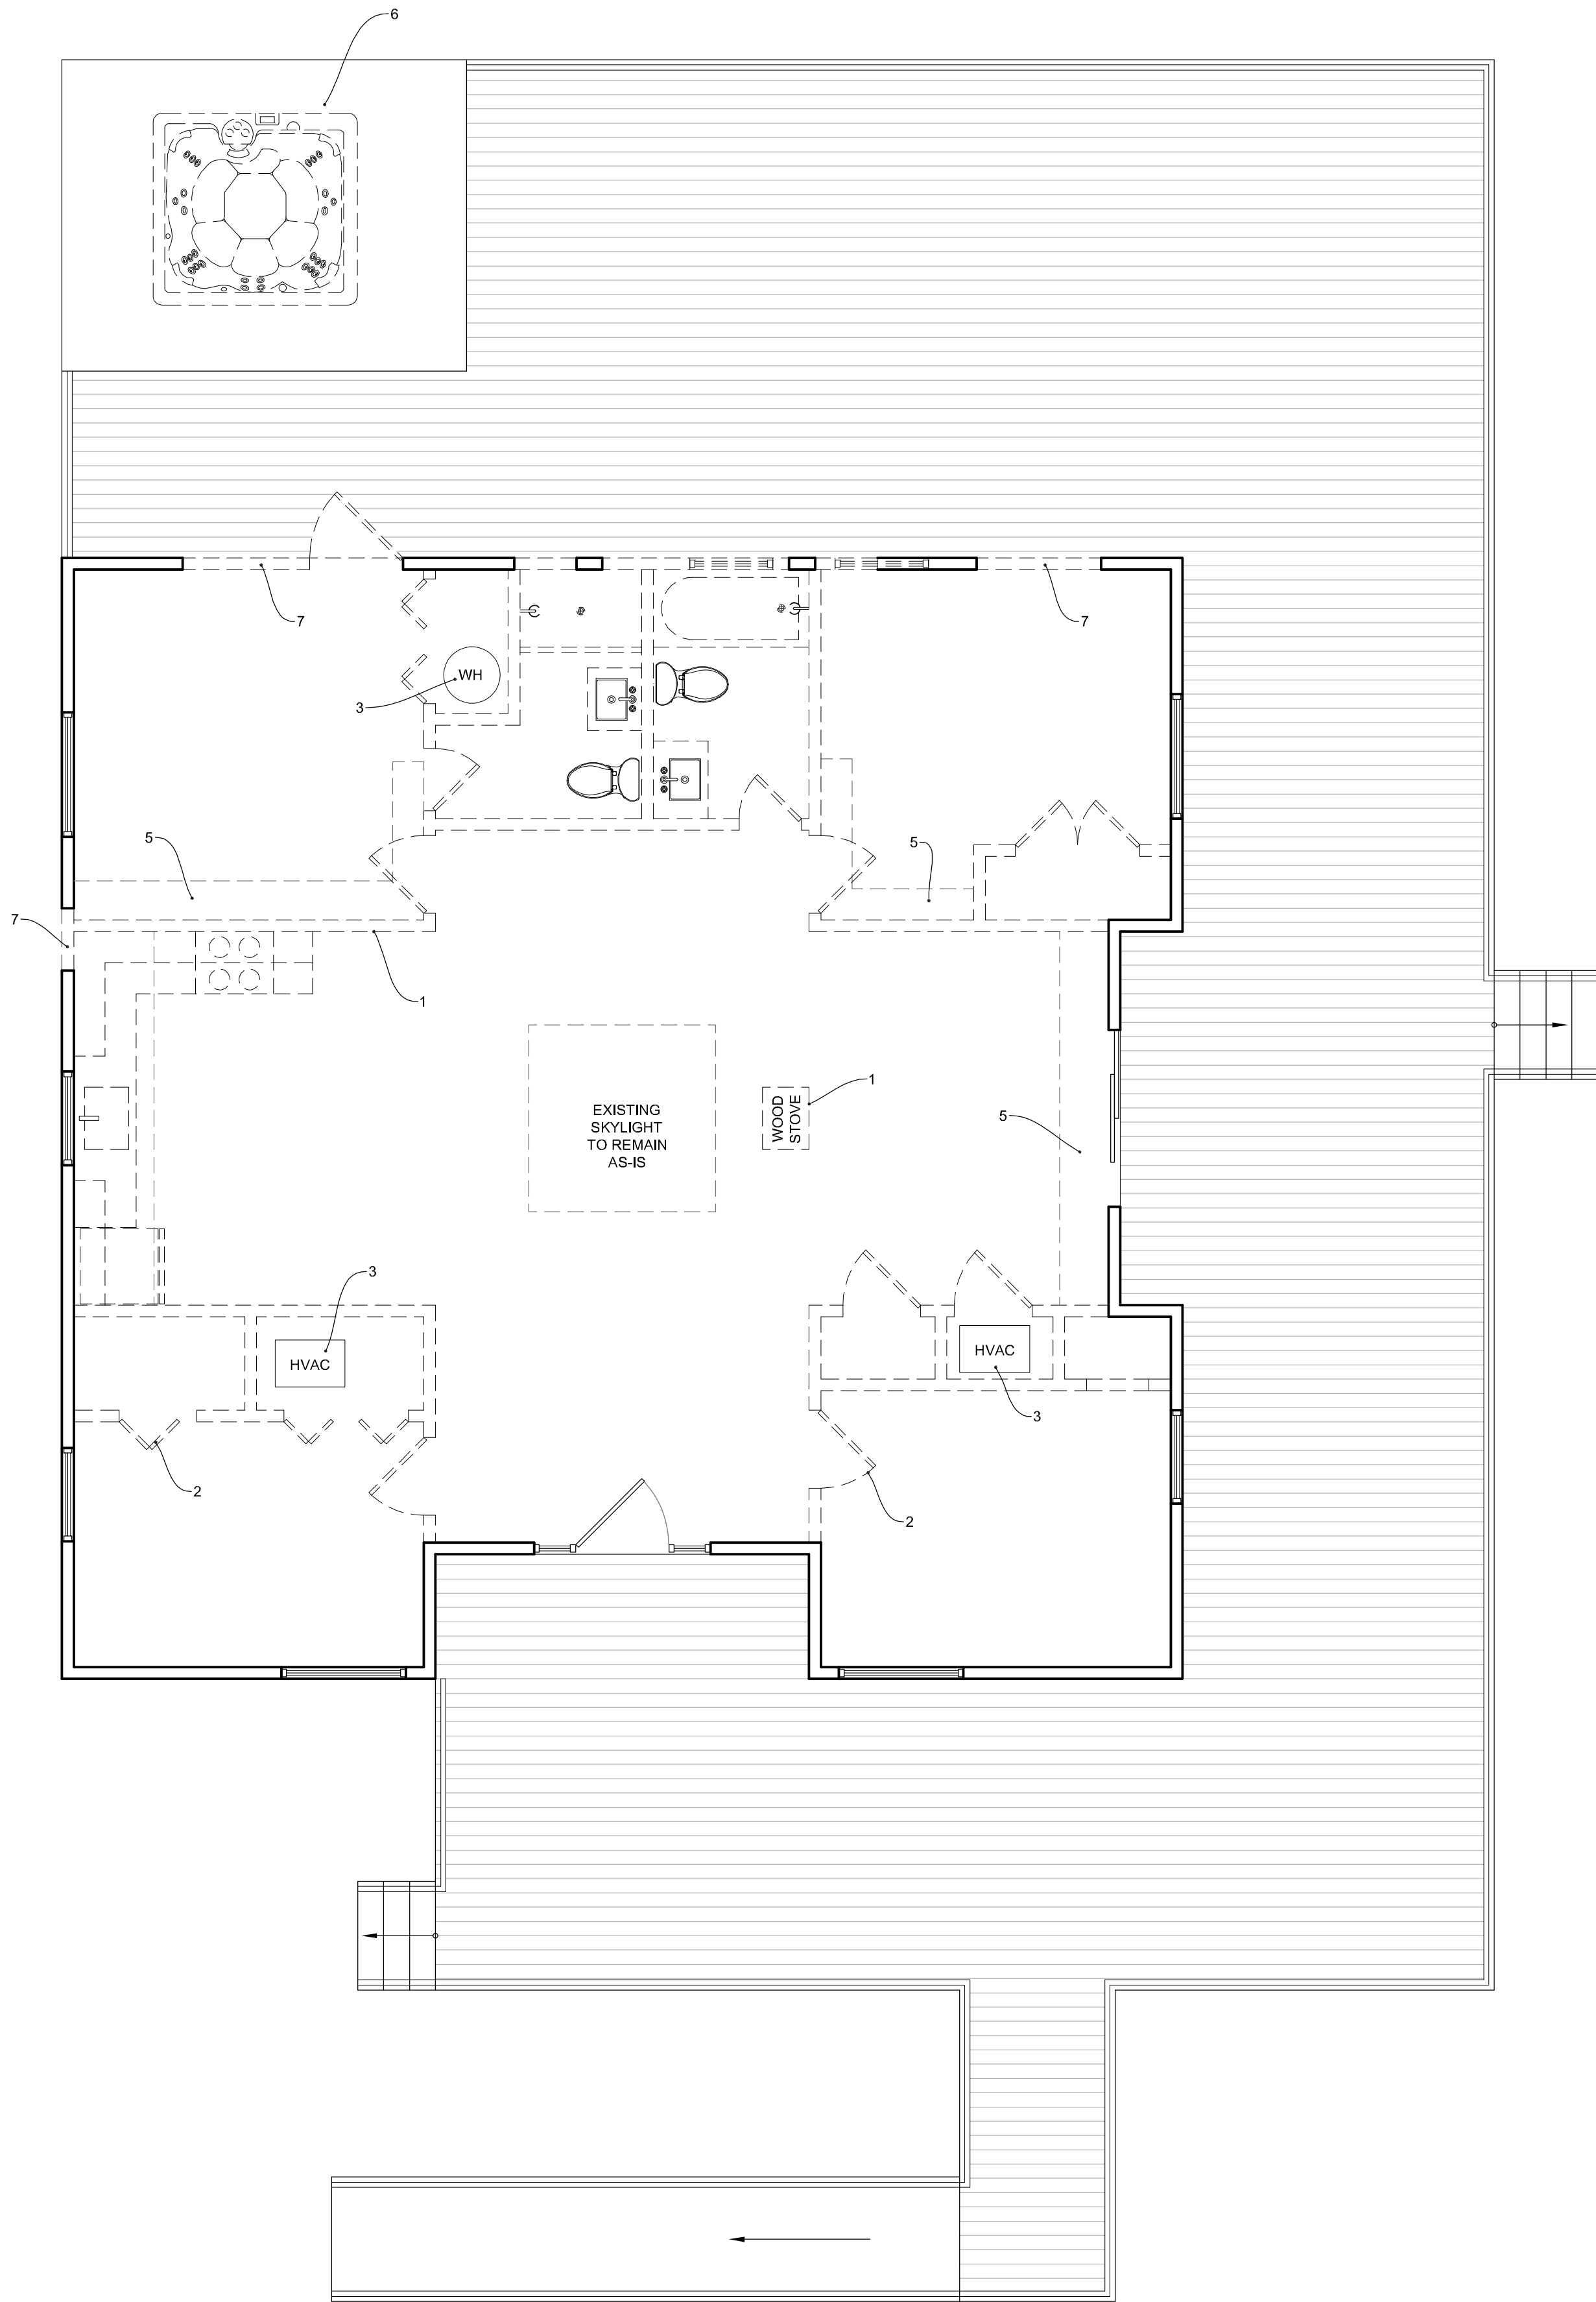

02
FIRST FLOOR PLAN - DEMO
1/4" = 1'-0"

DEMOLITION NOTES:

- GENERAL:
- REMOVE ALL INTERIOR FLOOR FINISHES
 - REMOVE ALL INTERIOR WALL FINISHES
 - REMOVE CEILING FINISH MATERIALS IN BATHROOMS
 - REMOVE ALL CABINETRY
 - REMOVE ALL COUNTERTOPS
 - REMOVE ALL PLUMBING FIXTURES AND PLUMBING LINES ABOVE THE EXISTING SUBFLOOR
1. DEMO ALL INTERIOR WALL FRAMING, TYP.
 2. DEMO ALL INTERIOR DOORS, TYP.
 3. DEMO EXISTING HVAC EQUIPMENT
 4. DEMO EXISTING WATER HEATER
 5. DEMO ALL EXISTING BULKHEADS AND DUCTWORK, TYP.
 6. DEMO EXISTING HOT TUB STRUCTURE AND HOT TUB
 7. DEMO EXISTING HOT TUB STRUCTURE AND HOT TUB
 8. DEMO EXISTING WOOD STOVE AND CHIMNEY PIPE

GENERAL NOTES:

- ON-SITE VERIFICATION OF ALL DIMENSIONS AND CONDITIONS SHALL BE THE RESPONSIBILITY OF THE GENERAL CONTRACTOR AND HIS/HER SUBCONTRACTORS.
- NOTED DIMENSIONS TAKE PRECEDENCE OVER SCALE. DO NOT SCALE DRAWINGS.
- THE GENERAL NOTES AND TYPICAL DETAILS APPLY THROUGHOUT THE JOB UNLESS OTHERWISE NOTED OR SHOWN.
- DISCREPANCIES: THE CONTRACTOR SHALL COMPARE AND COORDINATE ALL DRAWINGS; WHEN IN THE OPINION OF THE CONTRACTOR, A DISCREPANCY EXISTS HE/SHE SHALL PROMPTLY REPORT IT TO THE ARCHITECT AND/OR DESIGNER FOR PROPER ADJUSTMENT BEFORE PROCEEDING WITH THE WORK.



MARCOGRADY.COM
703.729.5124
ASHBURN, VA 20147
+
TRAVERSE CITY, MI 49684

ALGONKIAN CABIN RENOVATION
CABIN #10
46442 PARK CHALET PL
STERLING, VA 20165



DATE	ISSUE
06.19.26	CLIENT REVIEW
08.12.26	CLIENT REVIEW
08.13.26	FOR PERMIT

This is an original design and may not be used or copied under penalty of law. Drawings, specifications, and all other instruments of service are and shall remain the physical and intellectual property of MARCO O'GRADY DESIGN whether the projects for which they are created are executed or not.
© 2025-2026 MARCO O'GRADY DESIGN



01

FRONT ELEVATION - EXISTING


1/4" = 1'-0"



02

RIGHT SIDE ELEVATION - EXISTING


1/4" = 1'-0"

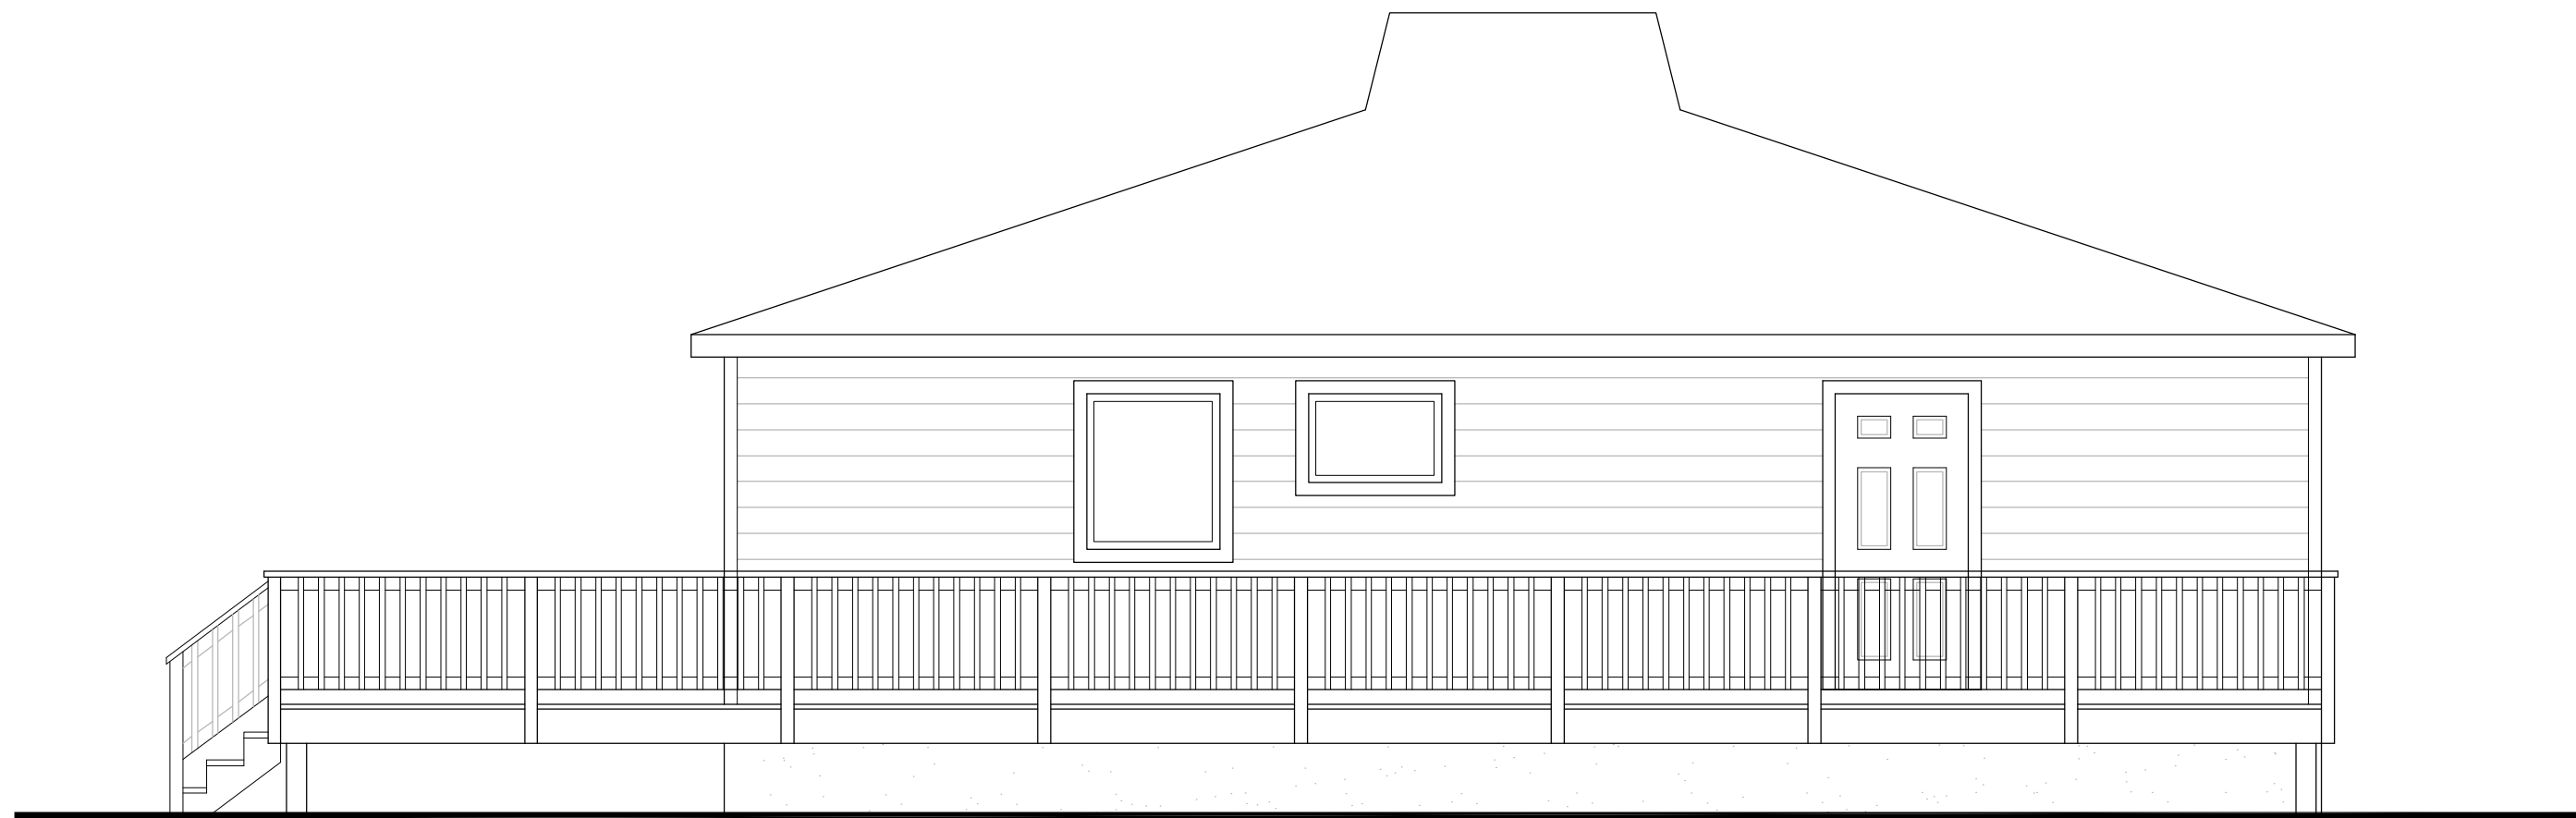

03

REAR ELEVATION - EXISTING


1/4" = 1'-0"

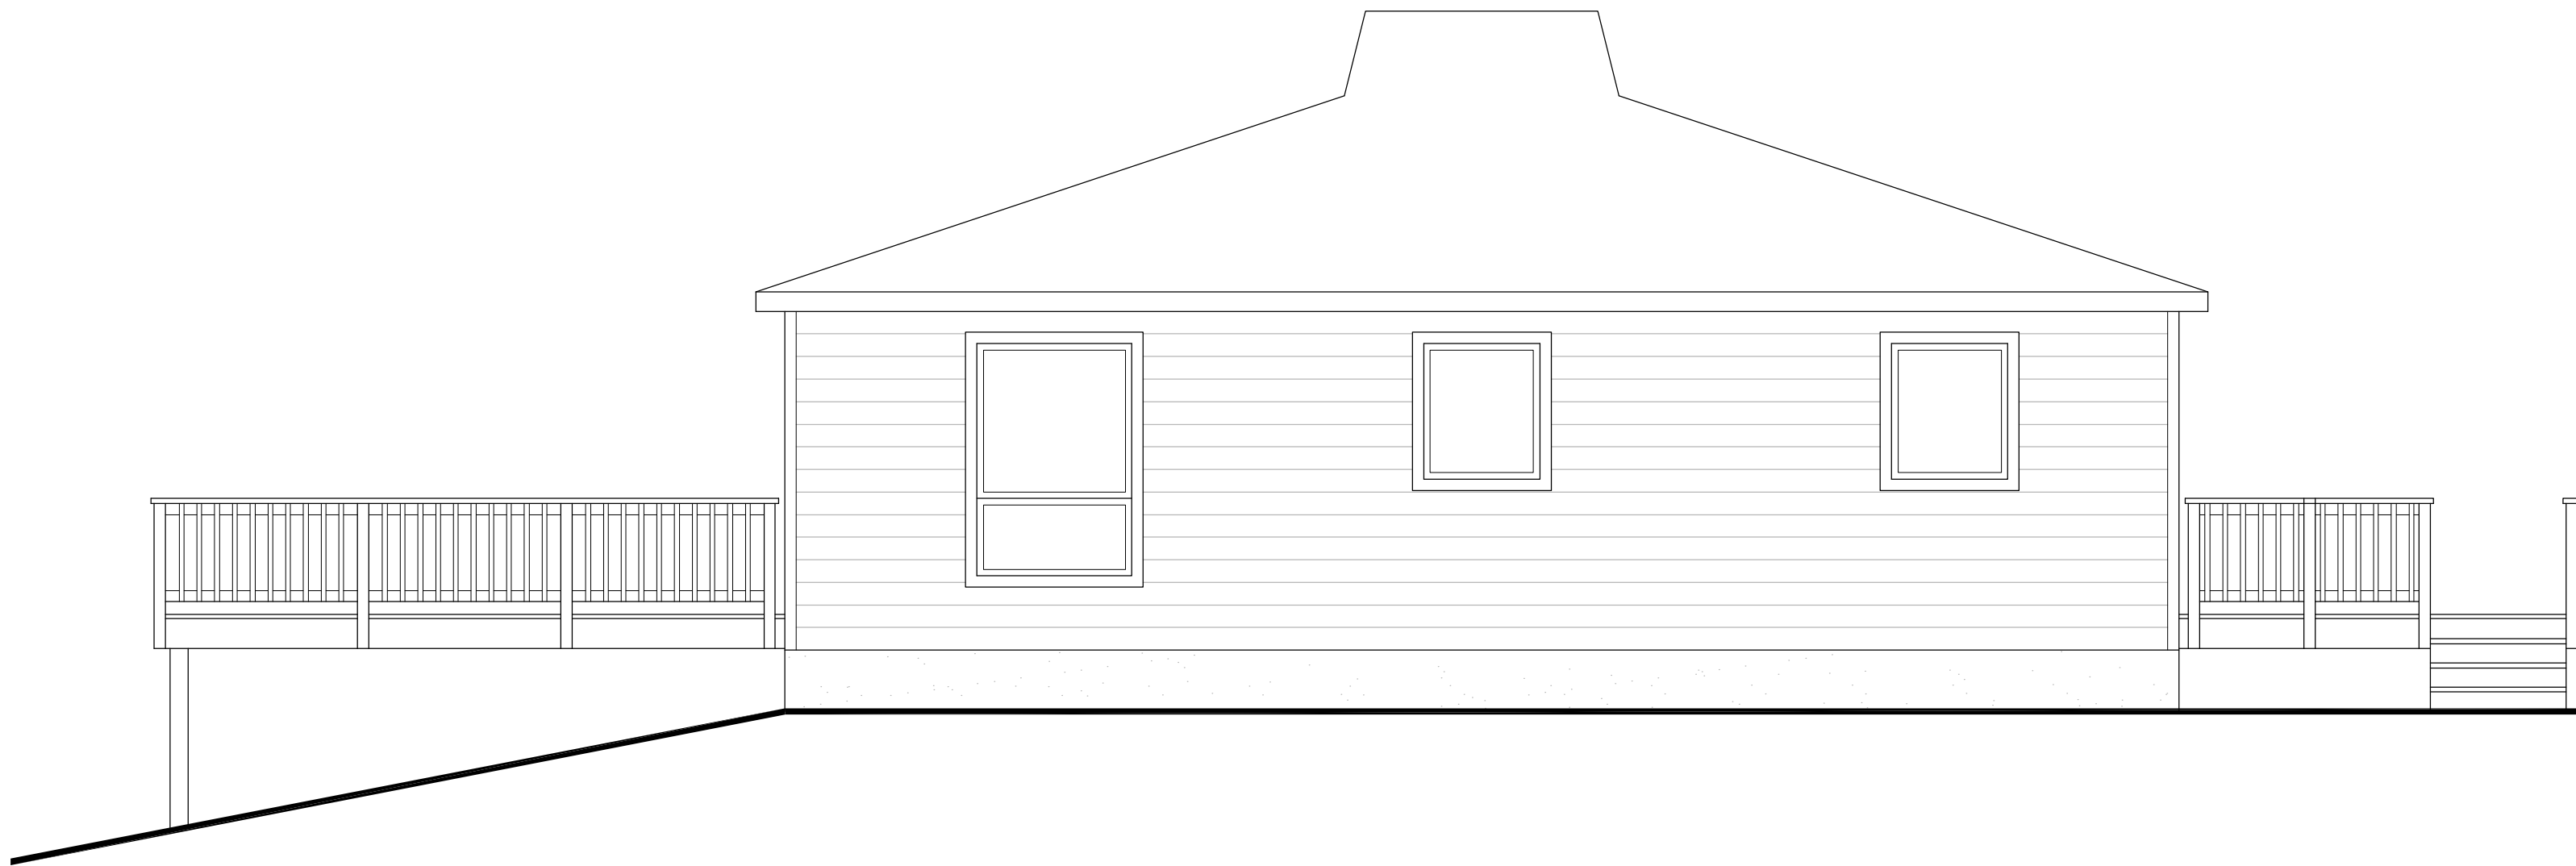

04

LEFT SIDE ELEVATION - EXISTING

1/4" = 1'-0"

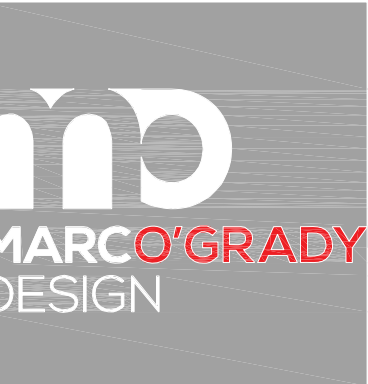

MARCOGRADY.COM
703.729.5124

ASHBURN, VA 20147
+
TRAVERSE CITY, MI 49684

ALGONKIAN CABIN RENOVATION
CABIN #10
46442 PARK CHALET PL
STERLING, VA 20165



DATE	ISSUE
06.19.26	CLIENT REVIEW
08.12.26	CLIENT REVIEW
08.13.26	FOR PERMIT

This is an original design and may not be used or copied under penalty of law. Drawings, specifications, and all other instruments of service are and shall remain the physical and intellectual property of MARCO O'GRADY DESIGN whether the projects for which they are created are executed or not.
© 2025-2026 MARCO O'GRADY DESIGN

A2

DOOR SCHEDULE

TAG	QUANTITY	TYPE	STYLE	WIDTH	HEIGHT	R.O. WIDTH	R.O. HEIGHT	SWING	MATERIAL	COLOR	NOTES
D1	1	EXTERIOR	ENTRY	3'-0"	6'-8"	39"	83"	LEFT HAND	TBD	TBD	
D2	1	EXTERIOR	PATIO	6'-0"	6'-8"	75"	83"	DOUBLE	TBD	TBD	SLIDING PATIO DOOR
D3	2	INTERIOR	BEDROOM	2'-6"	6'-8"	33"	83"	LEFT HAND	TBD	TBD / PAINT	
D4	1	INTERIOR	BEDROOM	2'-6"	6'-8"	33"	83"	RIGHT HAND	TBD	TBD / PAINT	
D5	1	INTERIOR	BATHROOM	2'-4"	6'-8"	31"	83"	LEFT HAND	TBD	TBD / PAINT	
D6	1	INTERIOR	BATHROOM	2'-4"	6'-8"	31"	83"	RIGHT HAND	TBD	TBD / PAINT	
D7	2	INTERIOR	CLOSET	4'-0"	6'-8"	51"	83"	DOUBLE	TBD	TBD / PAINT	
D8	1	EXTERIOR	PATIO	VERIFY	6'-8"	VERIFY	83"	DOUBLE	TBD	TBD	SLIDING PATIO DOOR (VERIFY EXISTING OPENING)
TOTAL	10										

NOTE: FINAL DOOR SELECTIONS TO BE APPROVED BY HOMEOWNER


NOTE: ALL INTERIOR DOORS TO BE SOLID CORE UNLESS NOTED OTHERWISE

WINDOW SCHEDULE

TAG	QUANTITY	WIDTH	HEIGHT	TYPE	R.O. SIZE	EGRESS	MULLED	COLOR (EXT / INT)	NOTES
W1	1	3'-0"	2'-0"	AWNING	PER MFR	NO	NO	MATCH EXISTING	MATCH EXISTING WINDOWS (VERIFY)
W2	3	2'-0"	3'-6"	TRANSOM	PER MFR	NO	NO	MATCH EXISTING	MATCH EXISTING WINDOWS (VERIFY)
W3	1	6'-0"	2'-0"	PICTURE	PER MFR	NO	NO	MATCH EXISTING	MATCH EXISTING WINDOWS (VERIFY)
W4	1	4'-0"	3'-0"	PICTURE	PER MFR	NO	NO	MATCH EXISTING	MATCH EXISTING WINDOWS (VERIFY)
TOTAL	6								

NOTE: FINAL WINDOW SELECTIONS TO BE APPROVED BY HOMEOWNER

EGRESS WINDOWS: MEET OR EXCEED CLEAR OPENING AREA OF 5.7sf, MINIMUM CLEAR OPENING WIDTH OF 20" AND CLEAR OPENING HEIGHT OF 24"

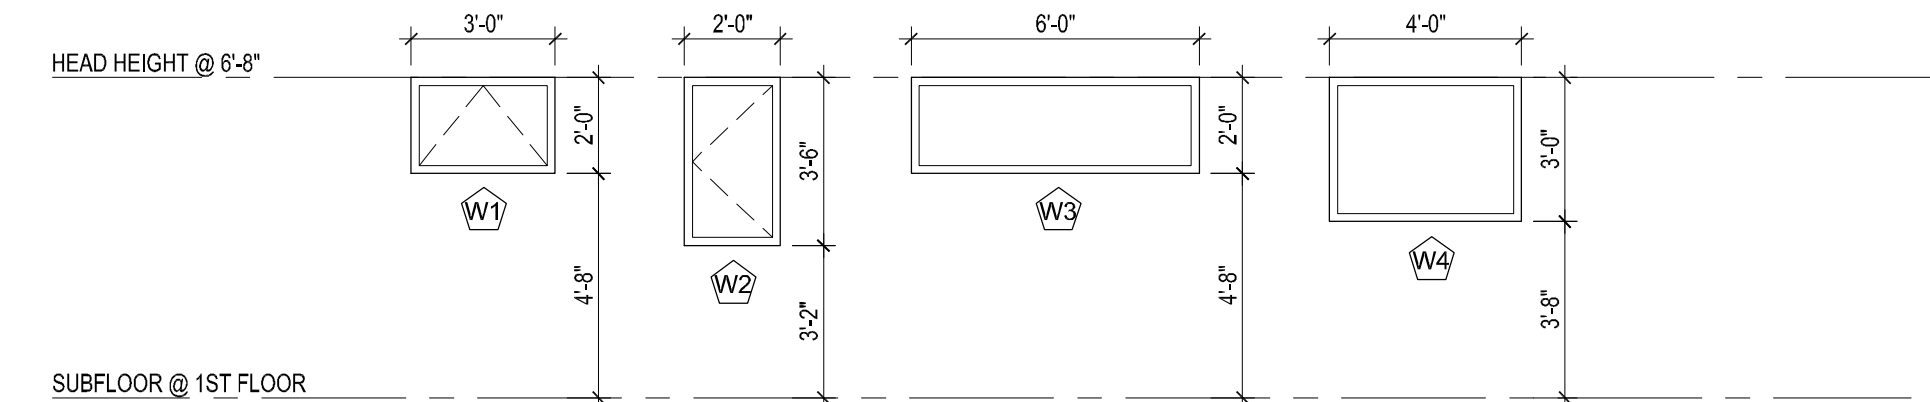

SUBFLOOR @ 1ST FLOOR



* WINDOW SIZES ARE NOMINAL
* MATCH EXISTING WINDOW COLOR + STYLE

GENERAL NOTES:

- ON-SITE VERIFICATION OF ALL DIMENSIONS AND CONDITIONS SHALL BE THE RESPONSIBILITY OF THE GENERAL CONTRACTOR AND HIS/HER SUBCONTRACTORS.
- NOTED DIMENSIONS TAKE PRECEDENCE OVER SCALE. DO NOT SCALE DRAWINGS.
- THE GENERAL NOTES AND TYPICAL DETAILS APPLY THROUGHOUT THE JOB UNLESS OTHERWISE NOTED OR SHOWN.
- DISCREPANCIES: THE CONTRACTOR SHALL COMPARE AND COORDINATE ALL DRAWINGS; WHEN IN THE OPINION OF THE CONTRACTOR, A DISCREPANCY EXISTS HE/SHE SHALL PROMPTLY REPORT IT TO THE ARCHITECT AND/OR DESIGNER FOR PROPER ADJUSTMENT BEFORE PROCEEDING WITH THE WORK.

WOOD RAILING TO MATCH EXISTING
AT AREA OF NEW DECK INFILL
(VERIFY IN FIELD)

PT WOOD DECKING TO MATCH EXISTING
AT AREA OF NEW DECK INFILL
(VERIFY IN FIELD)

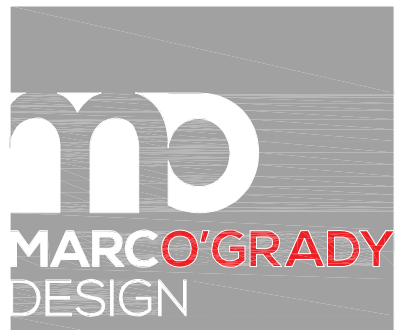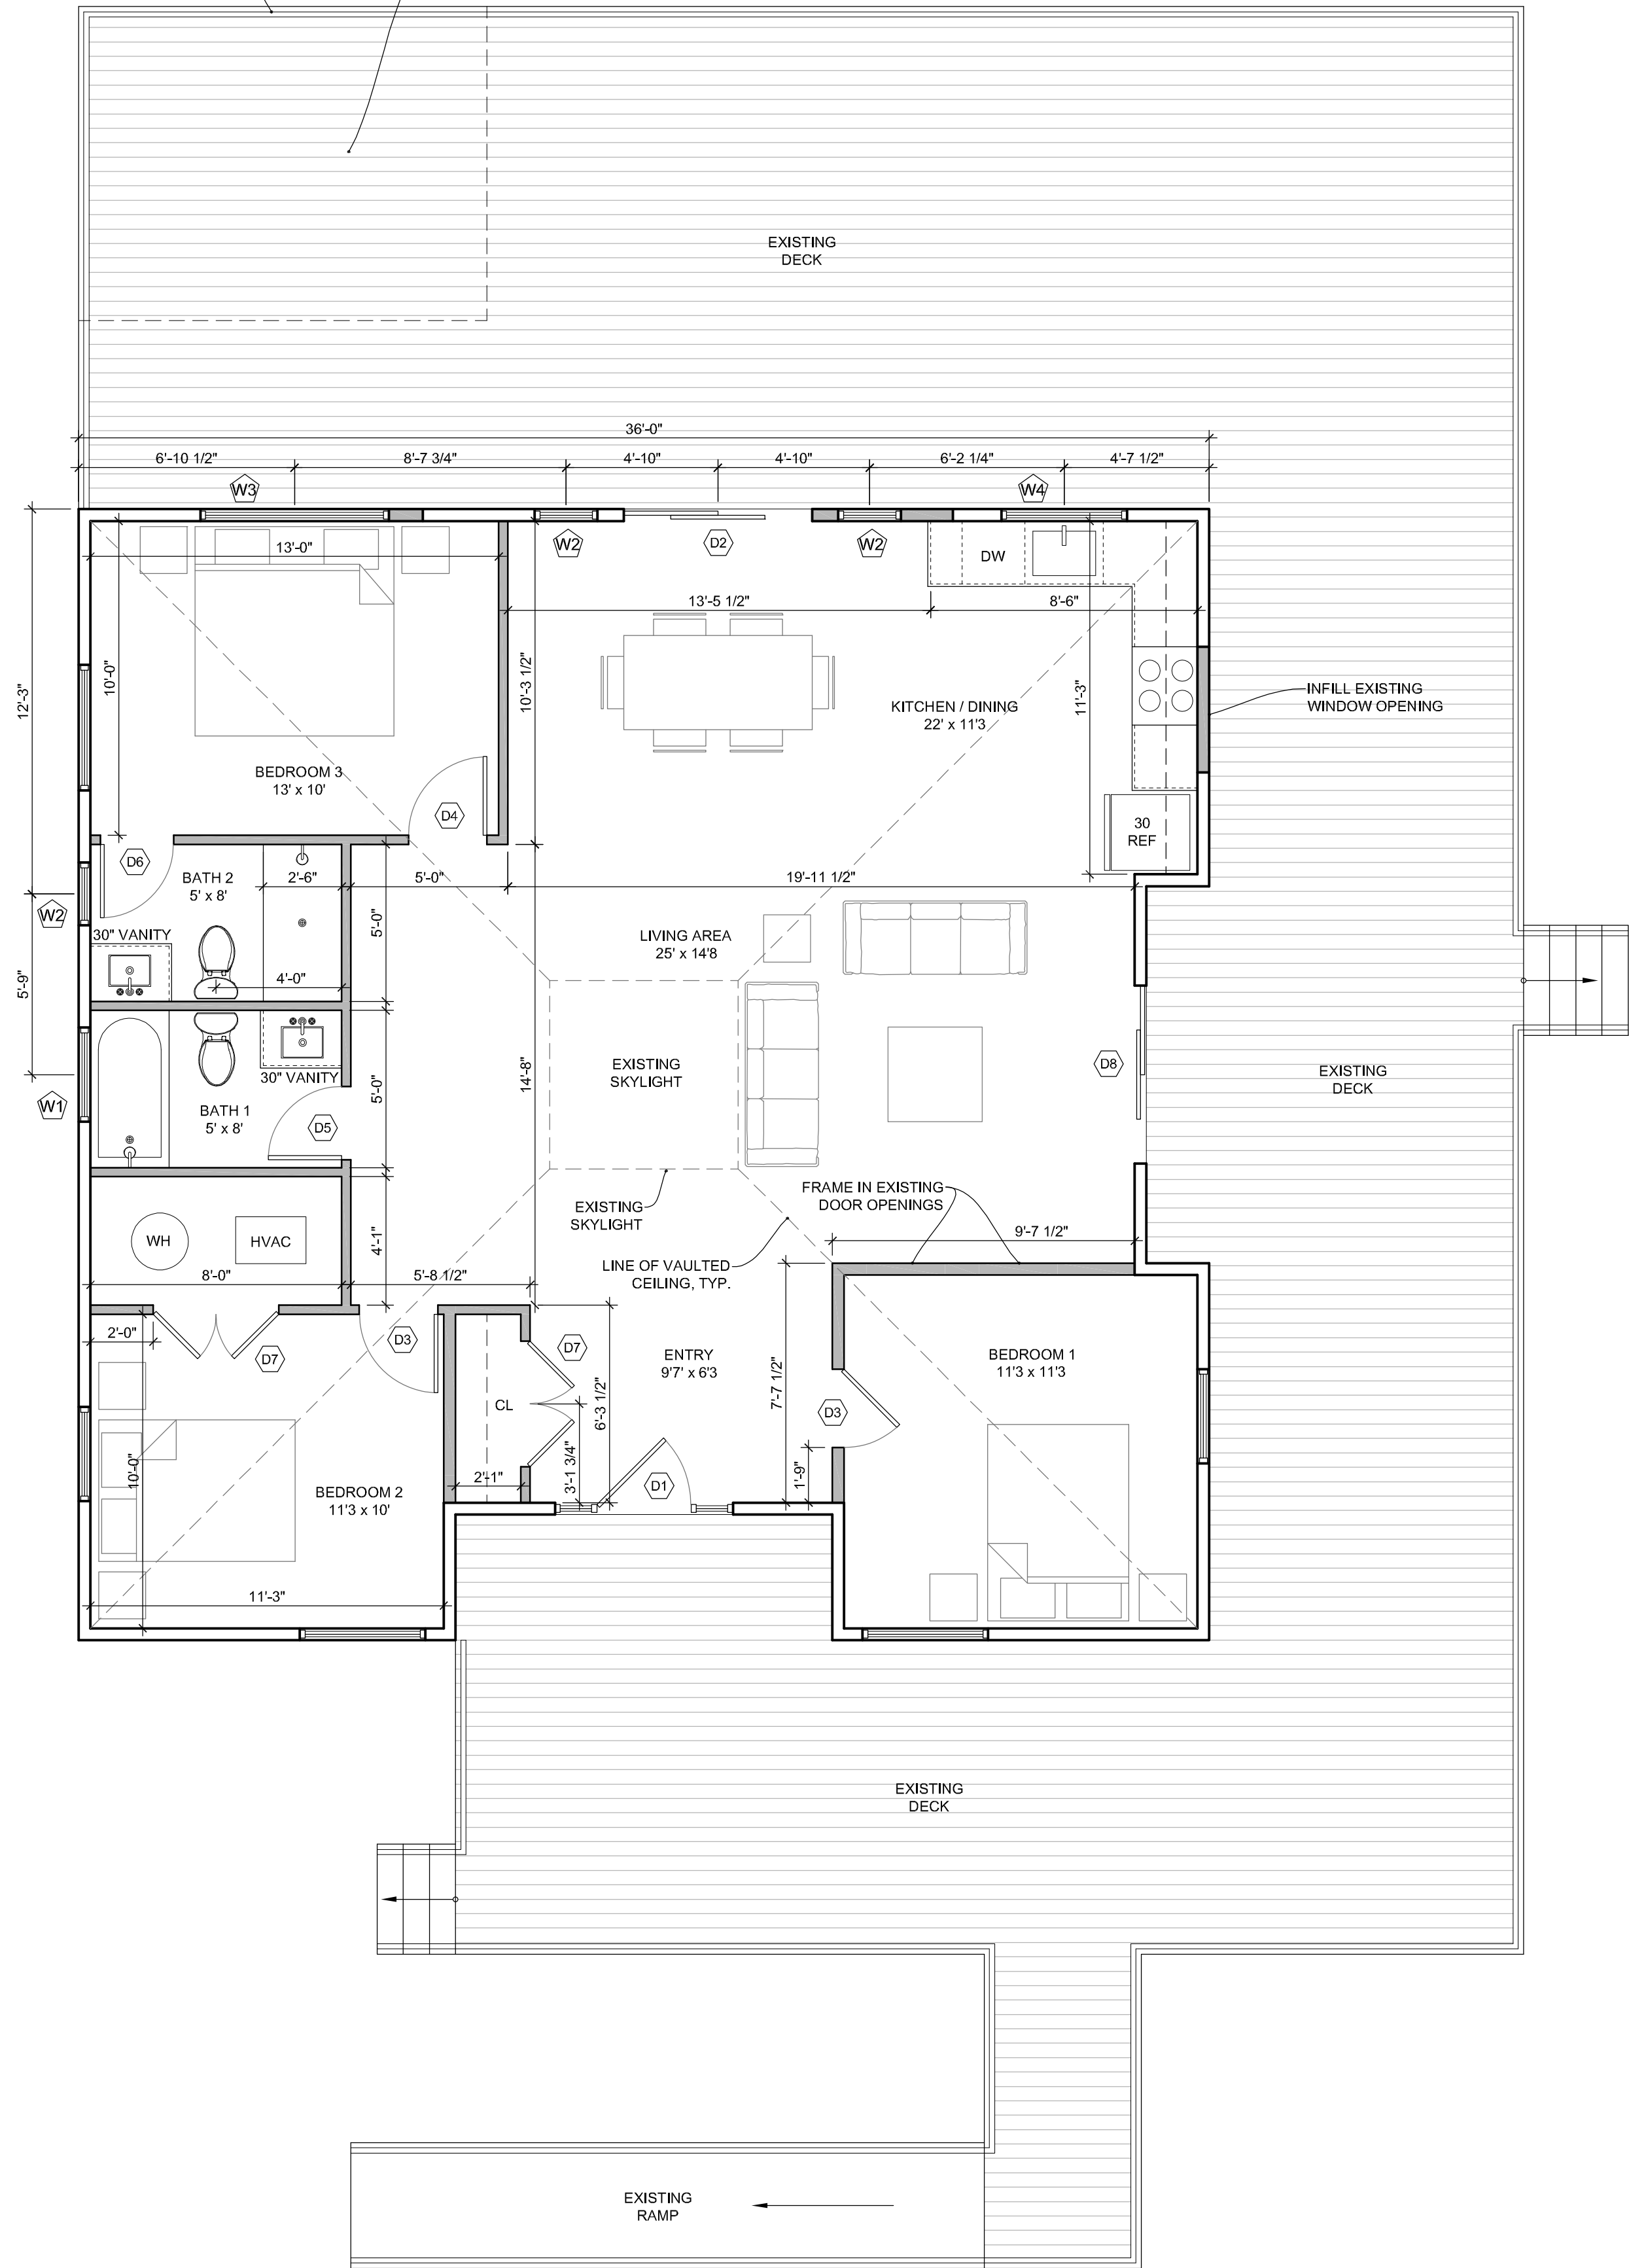

MARCOGRADY.COM
703.729.5124

ASHBURN, VA 20147
+
TRAVERSE CITY, MI 49684

ALGONKIAN CABIN RENOVATION
CABIN #10
46442 PARK CHALET PL
STERLING, VA 20165



DATE	ISSUE
06.19.26	CLIENT REVIEW
08.12.26	CLIENT REVIEW
08.13.26	FOR PERMIT

This is an original design and may not be used or copied under penalty of law. Drawings, specifications, and all other instruments of service are and shall remain the physical and intellectual property of MARCO O'GRADY DESIGN whether the projects for which they are created are executed or not.

© 2025-2026 MARCO O'GRADY DESIGN

A3

ALGONKIAN CABIN RENOVATION

CABIN #10
46442 PARK CHALET PL
STERLING, VA 20165



DATE	ISSUE
06.19.26	CLIENT REVIEW
08.12.26	CLIENT REVIEW
08.13.26	FOR PERMIT

This is an original design and may not be used or copied under penalty of law. Drawings, specifications, and all other instruments of service are and shall remain the physical and intellectual property of MARCO O'GRADY DESIGN whether the projects for which they are created are executed or not.


© 2025-2026 MARCO O'GRADY DESIGN




01
FRONT ELEVATION - PROPOSED
1/4" = 1'-0"



02
RIGHT SIDE ELEVATION - PROPOSED
1/4" = 1'-0"

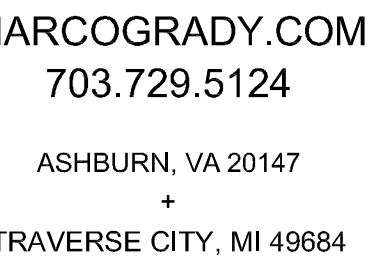

CABIN #10
46442 PARK CHALET PL
STERLING, VA 20165

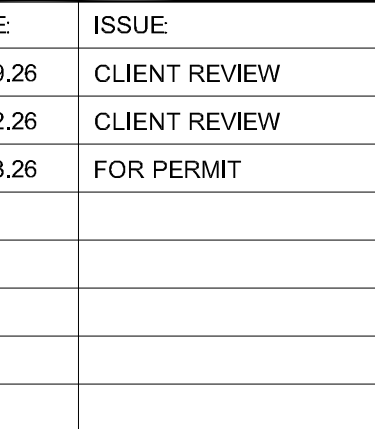


This is an original design and may not be used or copied under penalty of law. Drawings, specifications, and all other instruments of service are and shall remain the physical and intellectual property of MARC O'GRADY DESIGN whether the projects for which they are created are executed or not.





2025-2026 MARC O'GRADY DESIGN

A5




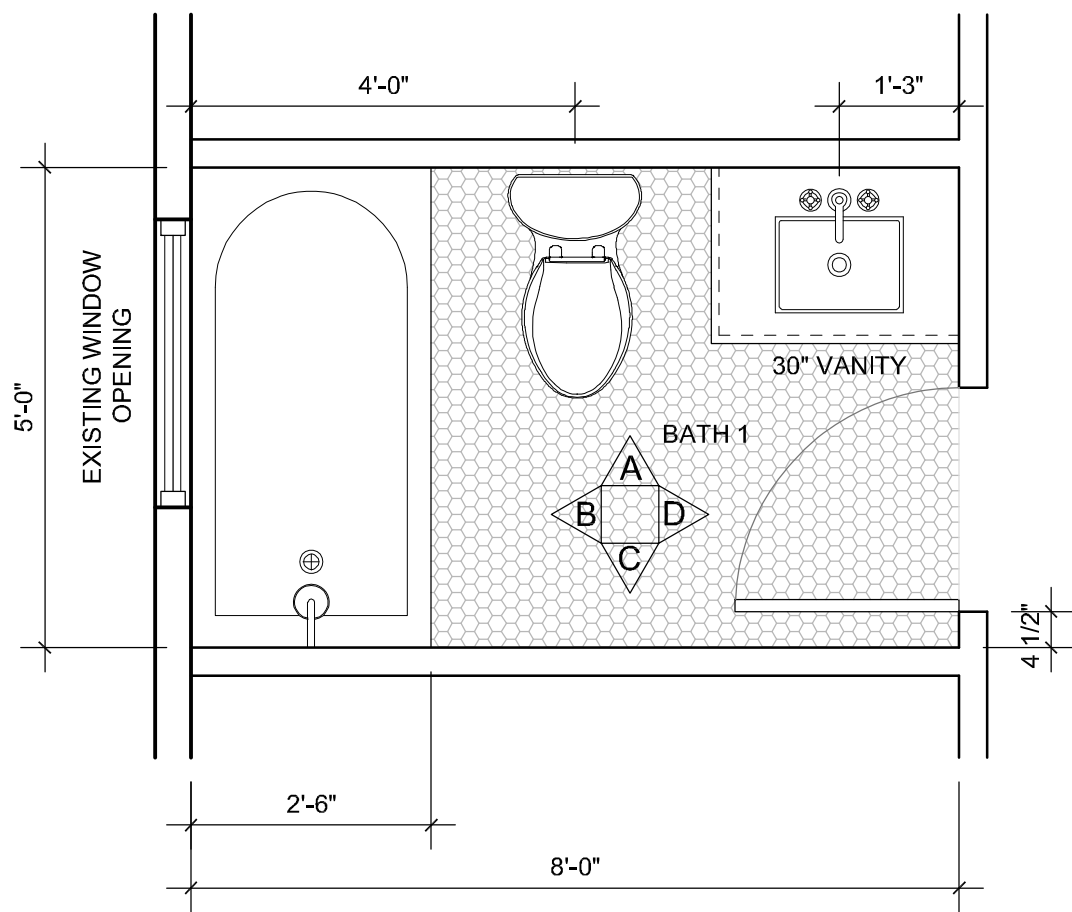





01
BATH 1 - ENLARGED PLAN
1/4" = 1'-0"

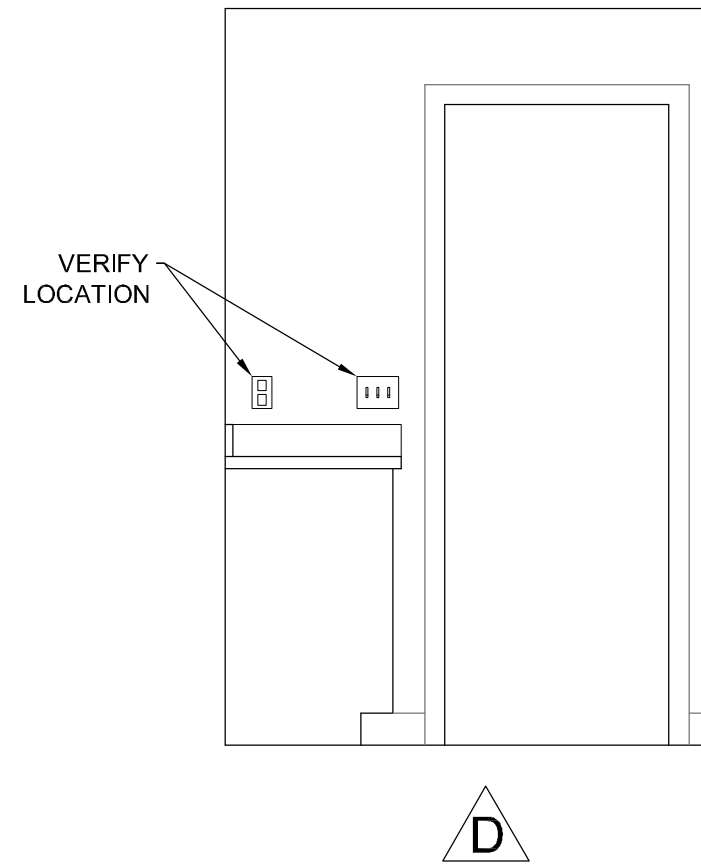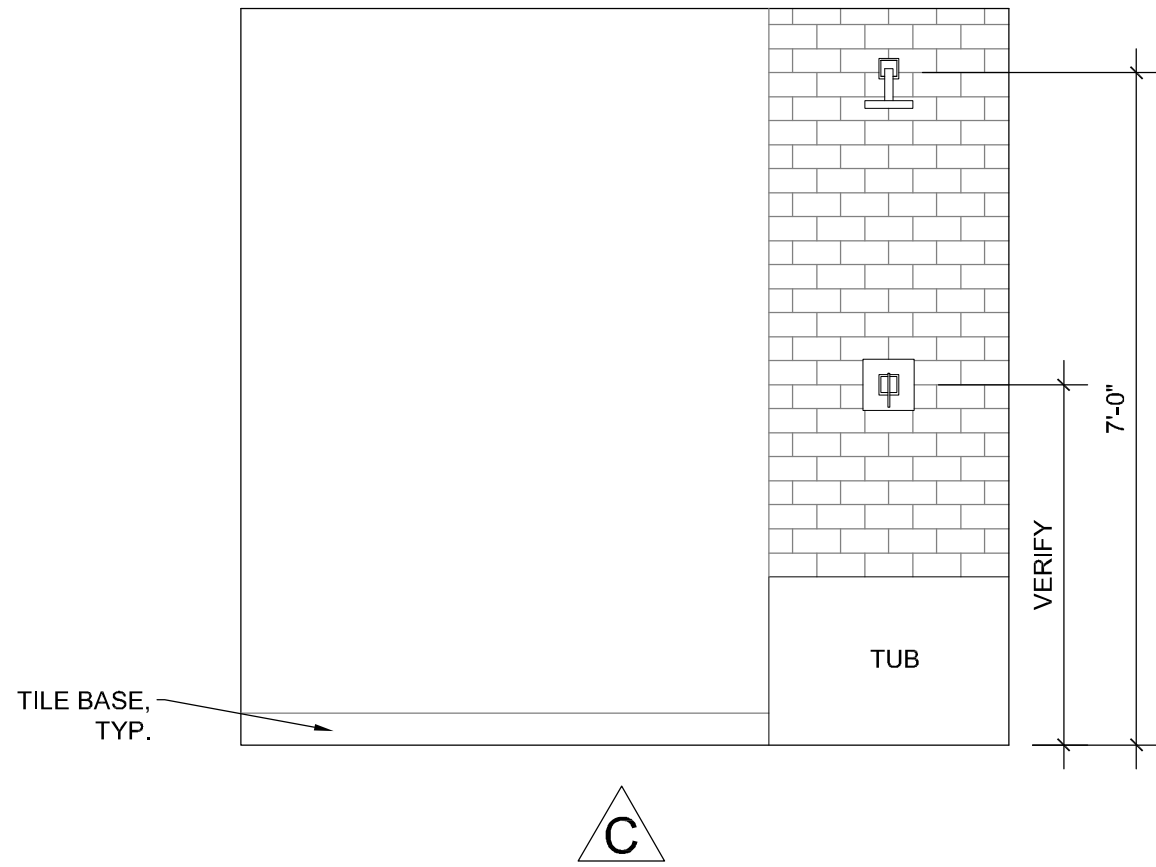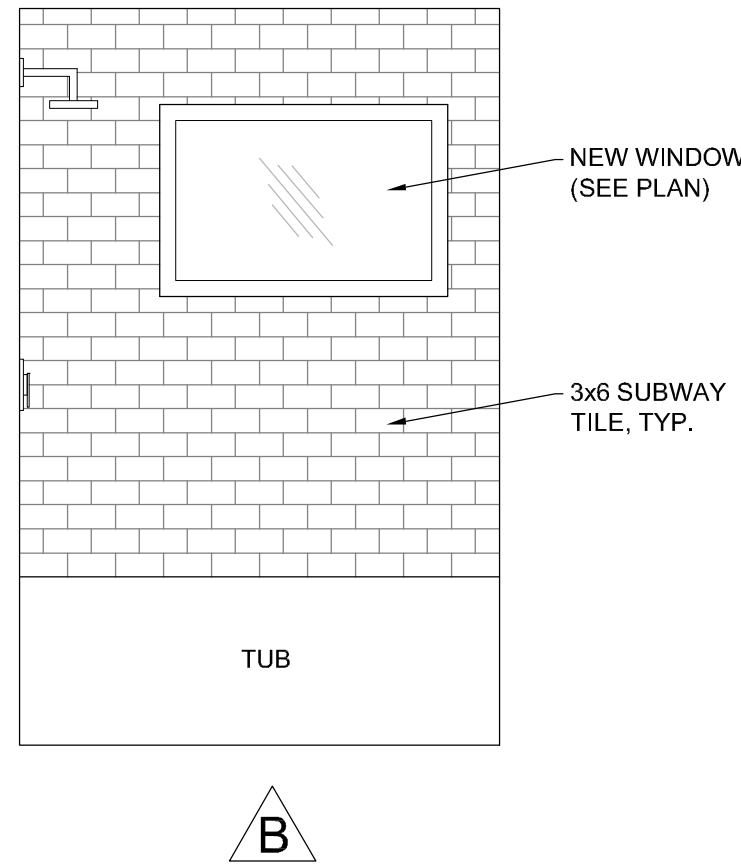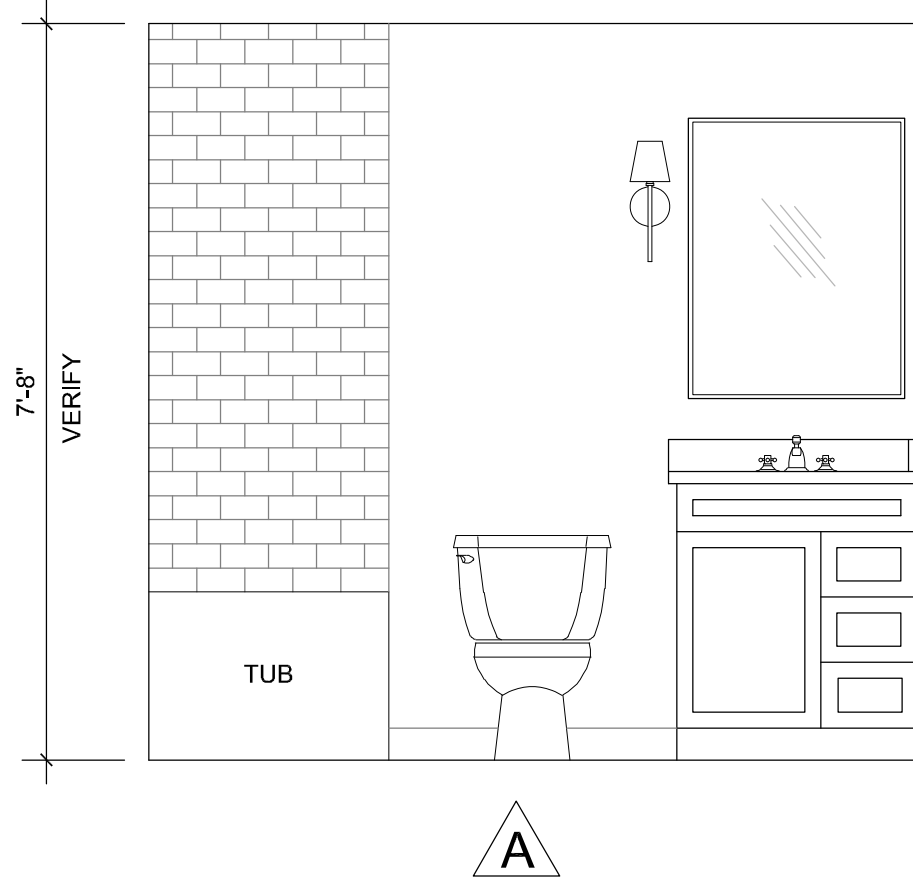


02
BATH 1 - ELEVATIONS
1/4" = 1'-0"

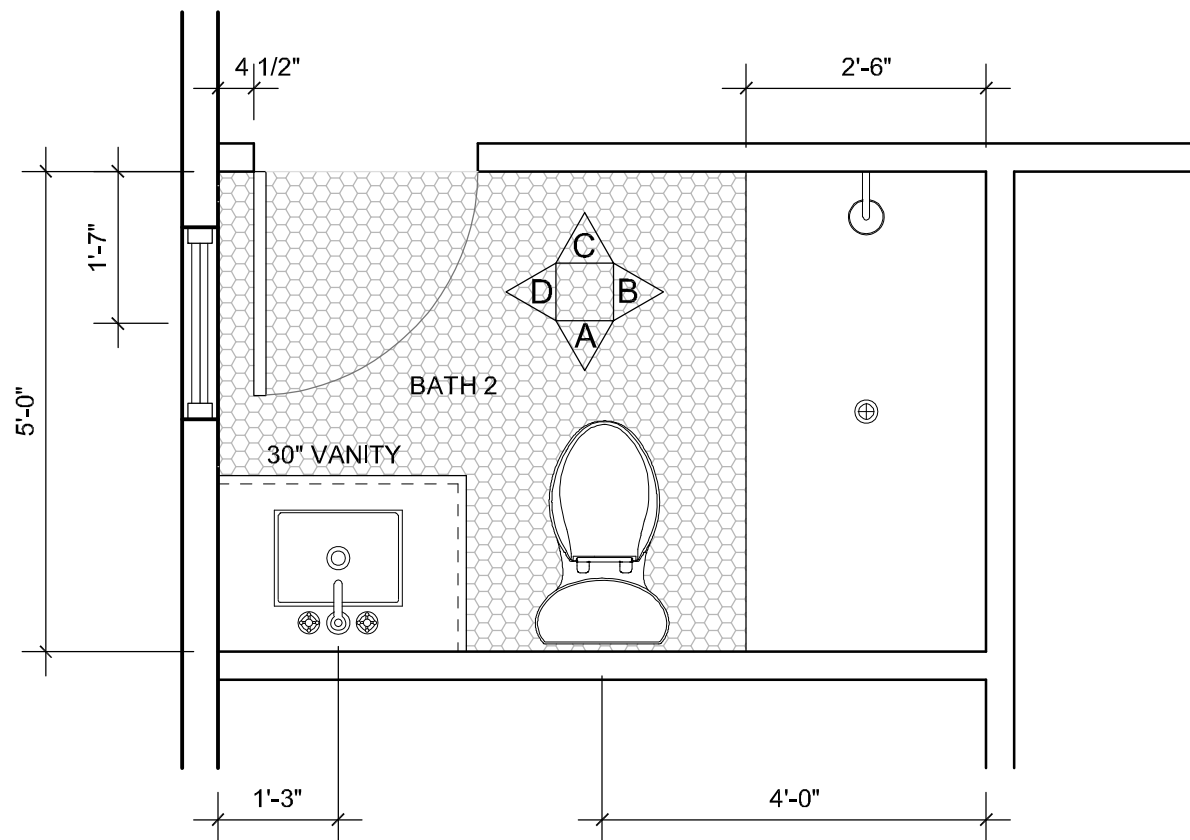


03
BATH 2 - ENLARGED PLAN
1/4" = 1'-0"

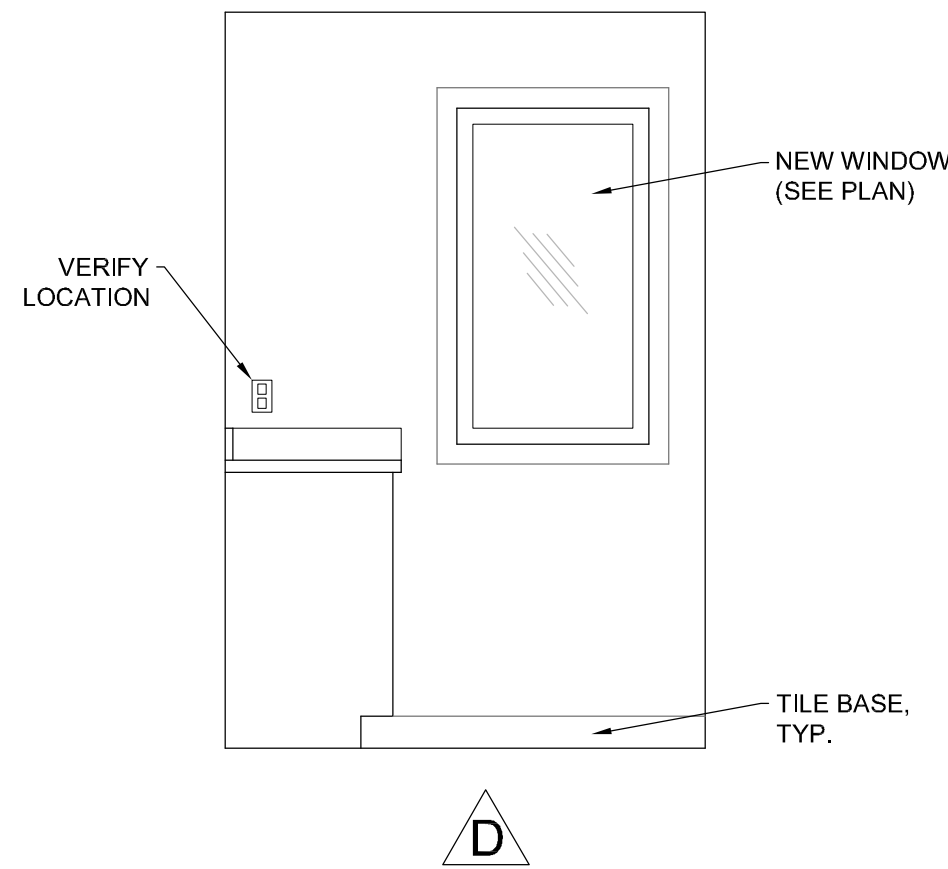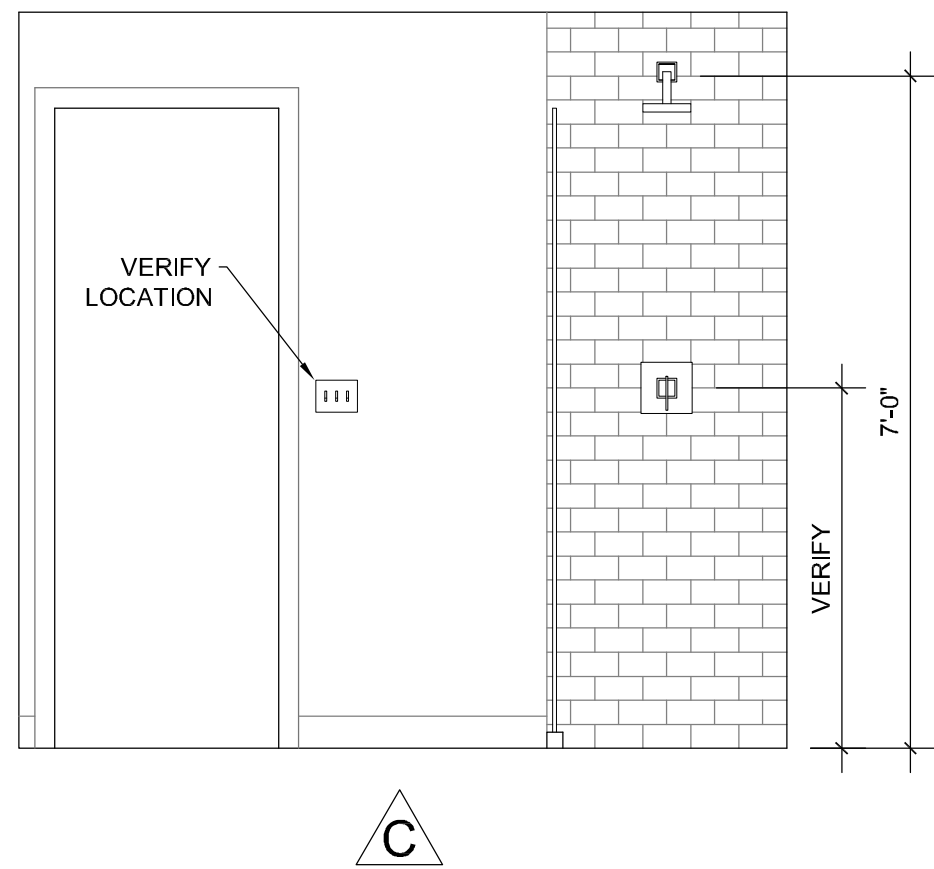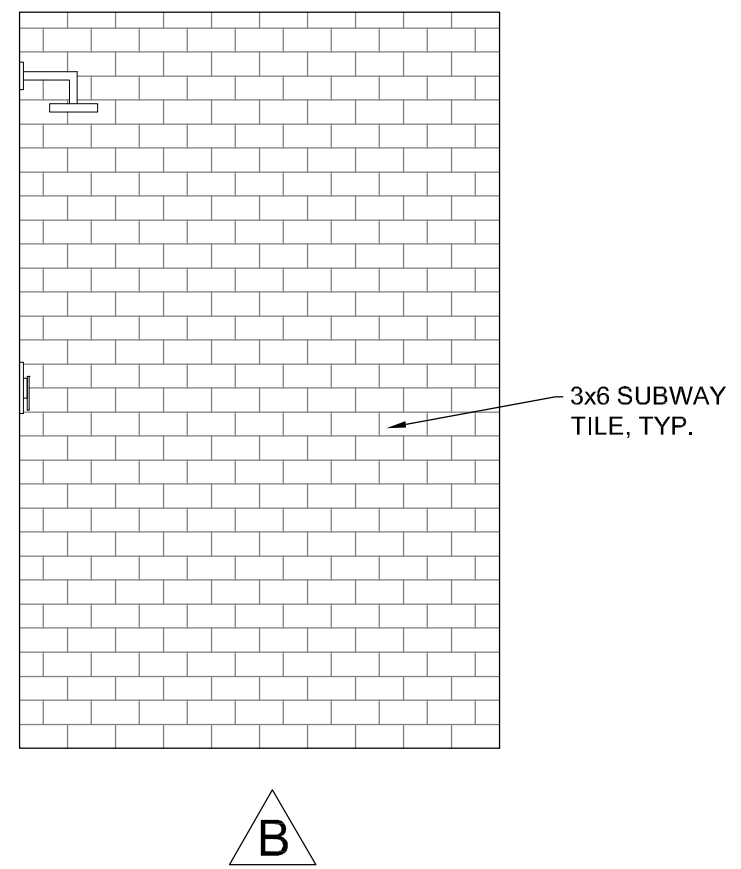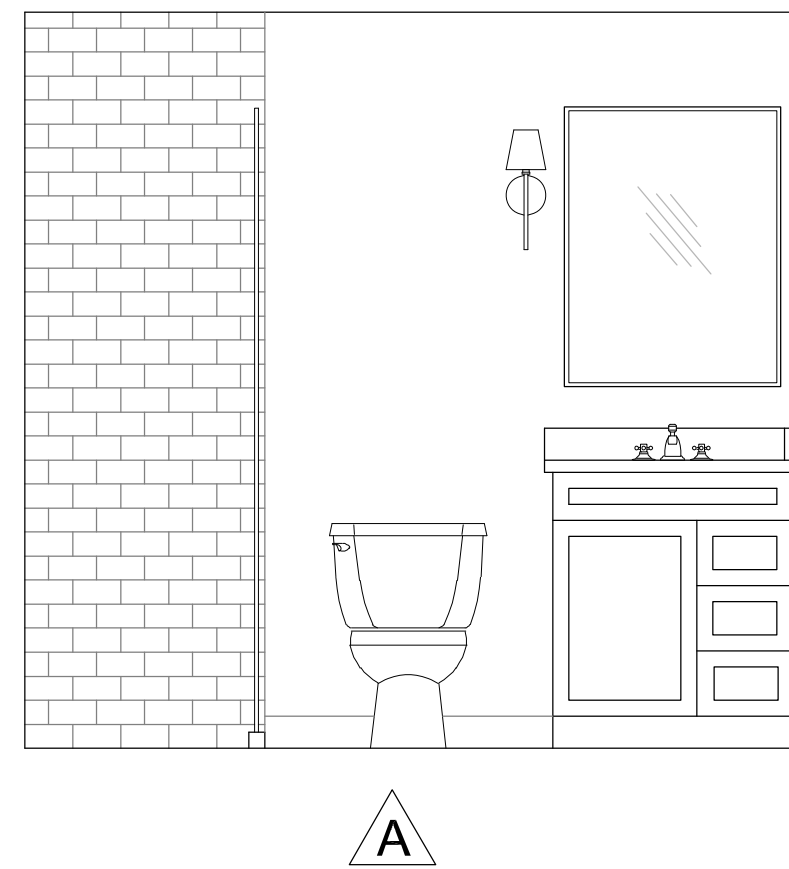

04
BATH 2 - ELEVATIONS
1/4" = 1'-0"

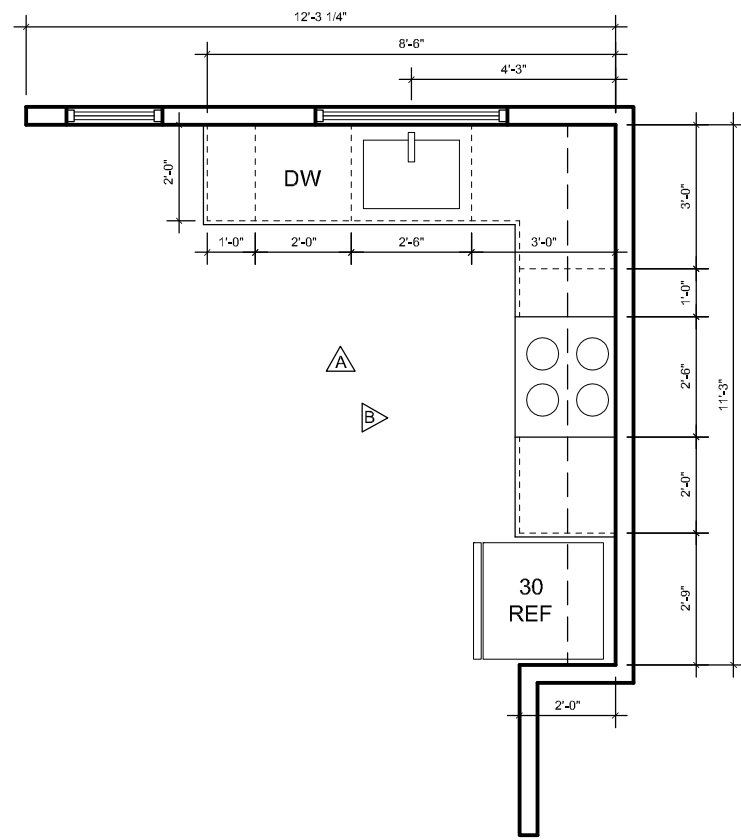

05
KITCHEN - ENLARGED PLAN
1/4" = 1'-0"

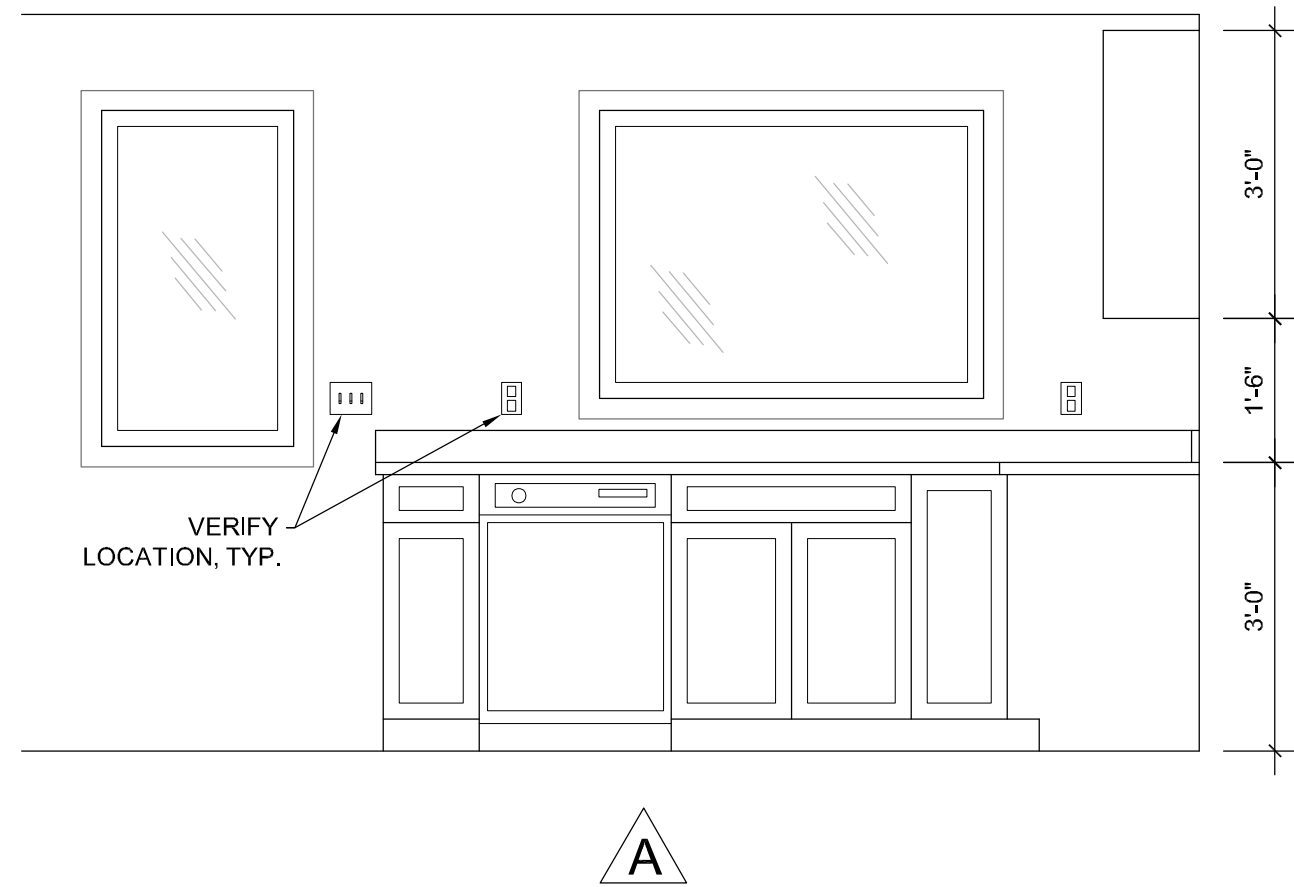

06
KITCHEN - ELEVATIONS
1/4" = 1'-0"



MARCOGRADY.COM
703.729.5124
ASHBURN, VA 20147
+ TRAVERSE CITY, MI 49684

ALGONKIAN CABIN RENOVATION
CABIN #10
46442 PARK CHALET PL
STERLING, VA 20165



DATE	ISSUE
06.19.26	CLIENT REVIEW
08.12.26	CLIENT REVIEW
08.13.26	FOR PERMIT

This is an original design and may not be used or copied under penalty of law. Drawings, specifications, and all other instruments of service are and shall remain the physical and intellectual property of MARCO O'GRADY DESIGN whether the projects for which they are created are executed or not.
© 2025-2026 MARCO O'GRADY DESIGN

A6

0	LOCATION	ROOM	ITEM	NOTES	BRAND	PRODUCT SELECTION	COLOR / FINISH	SKU/MODEL#	SUPPLIER / WEBSITE
1	1st FLOOR	ENTRY	FLOORING		Optimax Performance	Bradford Honey	Natural	101337228	Floor & Decor
2	1st FLOOR	ENTRY	LIGHT FIXTURE		Visual Comfort & Co.	Payton 1	Black	DJP1131MBK	Ferguson Home
3	1st FLOOR	KITCHEN	FLOORING		Optimax Performance	Bradford Honey	Natural	101337228	Floor & Decor
4	1st FLOOR	KITCHEN	CABINETS - KITCHEN		Hampton Bay	Avondale	White	TBD	Home Depot
4a	1st FLOOR	KITCHEN	CABINETS - KITCHEN		Custom Millwork	SEE LINK FOR CONCEPT	Natural wood/ wood look	TBD	Custom
5	1st FLOOR	KITCHEN	KNOB - CABINETS		Atlas	Malin	Black	A642-BRN	Ferguson Home
6	1st FLOOR	KITCHEN	COUNTERTOP		Cambria	Quartz - Seacourt	White variants	TBD	Home Depot
7	1st FLOOR	KITCHEN	SINK		Kohler	Billings	Black	K-33712-CM1	Ferguson Home
8	1st FLOOR	KITCHEN	FAUCET - SINK		Pfister	Montay Single Handle	Matte Black	GT-529-MTB	Ferguson Home
9	1st FLOOR	KITCHEN	RANGE		GE	30 in 4 burner element free	White	GRF400SVWW	Home Depot
9a	1st FLOOR	KITCHEN	RANGE	MICROWAVE	GE	profile 1.1 cu ft countertop	White	PCHK11S1WWW	Home Depot
10	1st FLOOR	KITCHEN	RANGE HOOD		ZLINE	30 in ducted vent range hood	White	KB4STX-WM-30	Home Depot
11	1st FLOOR	KITCHEN	DISHWASHER		GE	Profile 18" Built-In	White	PDT145SGLWW	Home Depot
12	1st FLOOR	KITCHEN	REFRIGERATOR		GE	19.2 cu ft Top Freezer Fridge	White	GIE18GTNRWW	Home Depot
13	1st FLOOR	KITCHEN	LIGHT FIXTURE	KITCHEN AREA	Visual Comfort & Co.	Astra 24" wide pendant	Black	DJP1281MBK	Ferguson Home
14	1st FLOOR	DINING	FLOORING		Optimax Performance	Bradford Honey	Natural	101337228	Floor & Decor
15	1st FLOOR	DINING	LIGHT FIXTURE	FIXTURE OVER DINING TABLE	Visual Comfort & Co.	Antonia Medium Linear Lantern	Aged Iron (Black)	CHC 2156AI	Ferguson Home
18	1st FLOOR	LIVING AREA	FLOORING		Optimax Performance	Bradford Honey	Natural /Honey	101337228	Floor & Decor
19	1st FLOOR	LIVING AREA	LIGHT FIXTURE	Ceiling Fan/Light	MinkaAire	Skinnie 56"	Coal	F626L-CL	Ferguson Home
23	1st FLOOR	LIVING AREA	SMOKE DETECTOR		Kidde	Hardwire Smoke + CO	White	21031529	Home Depot
24	1st FLOOR	BEDROOM 1	FLOORING		Optimax Performance	Bradford Honey	Natural/Honey	101337228	Floor & Decor
25	1st FLOOR	BEDROOM 1	LIGHT FIXTURE	Ceiling Fan/Light	MinkaAire	Skinnie 44"	Coal	F625L-CL	Ferguson Home
28	1st FLOOR	BEDROOM 1	SMOKE DETECTOR		Kidde	Hardwire Smoke + CO	White	21031529	Home Depot
29	1st FLOOR	BEDROOM 2	FLOORING		Optimax Performance	Bradford Honey	Natural/Honey	101337228	Floor & Decor
30	1st FLOOR	BEDROOM 1	LIGHT FIXTURE	Ceiling Fan/Light	MinkaAire	Skinnie 44"	Coal	F625L-CL	Ferguson Home
33	1st FLOOR	BEDROOM 2	SMOKE DETECTOR		Kidde	Hardwire Smoke + CO	White	21031529	Home Depot
34	1st FLOOR	BEDROOM 3	FLOORING		Optimax Performance	Bradford Honey	Natural/Honey	101337228	Floor & Decor
35	1st FLOOR	BEDROOM 1	LIGHT FIXTURE	Ceiling Fan/Light	MinkaAire	Skinnie 44"	Coal	F625L-CL	Ferguson Home
38	1st FLOOR	BEDROOM 3	SMOKE DETECTOR		Kidde	Hardwire Smoke + CO	White	21031529	Home Depot
39	1st FLOOR	BATH 1	CABINETS - VANITY			Pedestal or Concole Style	White/Brass		
40	1st FLOOR	BATH 1	SINK		Kingston Brass	Imperial	White	VPB4308	Ferguson Home
41	1st FLOOR	BATH 1	FAUCET - SINK		Signature Hardware	Lexia Widespread	Polished Brass	SHWSCLE808PB	Ferguson Home
42	1st FLOOR	BATH 1	TUB		Kohler	Irvine	White	K-26070-RA-0	Ferguson Home
43	1st FLOOR	BATH 1	FAUCET - TUB		Signature Hardware	Lexia Tub & Shower package	Polished Brass	SHLE8030GPB	Ferguson Home
44	1st FLOOR	BATH 1	SHOWER WALLS		Daltile	Restore 3x6 Subway Tile	Bright White	RE1536MODHD1P2	Home Depot
45	1st FLOOR	BATH 1	TOILET		Kohler	Memoirs Stately Comfort Height	White	K-3817-0	Ferguson Home
46	1st FLOOR	BATH 1	FLOORING - TILE		Daltile	Restore White Hex Mosaic	White w/ Grey Grout	RE151HEXHD1P2	Home Depot
47	1st FLOOR	BATH 1	LIGHT FIXTURE	Vanity Lighting (2)	Millenium Lighting	Adora 15"	Vintage Brass	16201-VB	Ferguson Home
48	1st FLOOR	BATH 1	MIRROR - VANITY		Pottery Barn	Vintage Rounded Rectangular Mirror	Antique Brass	6876932	Pottery Barn
49	1st FLOOR	BATH 1	EXHAUST FAN		Broan-Nutone	QT Series Quiet 120 CFM	White	QT130LE	Home Depot
50	1st FLOOR	BATH 2	CABINETS - VANITY			Pedestal or Concole Style	White/Brass		
51	1st FLOOR	BATH 2	SINK		Kingston Brass	Imperial	White	VPB4308	Ferguson Home
52	1st FLOOR	BATH 2	FAUCET - SINK		Signature Hardware	Lexia Widespread	Polished Brass	SHWSCLE808PB	Ferguson Home
53	1st FLOOR	BATH 2	SHOWER PAN		Kohler	Irvine	White	K-26070-RA-0	Ferguson Home
54	1st FLOOR	BATH 2	FAUCET - SHOWER		Signature Hardware	Shower package	Polished Brass	SHLE8020GPB	Ferguson Home
55	1st FLOOR	BATH 2	SHOWER WALLS		Daltile	Restore 3x6 Subway Tile	Bright White	RE1536MODHD1P2	Home Depot
55a	1st FLOOR	BATH 2	SHOWER GLASS		Glass Warehouse	Illume	Polished Brass	GW-WH-60-PB	Ferguson Home
56	1st FLOOR	BATH 2	TOILET		Kohler	Memoirs Stately Comfort Height	White	K-3817-0	Ferguson Home
57	1st FLOOR	BATH 2	FLOORING - TILE		Daltile	Restore White Hex Mosaic	White w/ Grey Grout	RE151HEXHD1P2	Home Depot
58	1st FLOOR	BATH 2	LIGHT FIXTURE	Vanity Lighting (2)	Millenium Lighting	Adora 15"	Vintage Brass	16201-VB	Ferguson Home
59	1st FLOOR	BATH 2	MIRROR - VANITY		Pottery Barn	Vintage Rounded Rectangular Mirror	Antique Brass	6876932	Pottery Barn
60	1st FLOOR	BATH 2	EXHAUST FAN		Broan-Nutone	QT Series Quiet 120 CFM	White	QT130LE	Home Depot



MARCOGRADY.COM
703.729.5124
ASHBURN, VA 20147
+
TRAVERSE CITY, MI 49684

ALGONKIAN CABIN RENOVATION
CABIN #10
46442 PARK CHALET PL
STERLING, VA 20165



DATE:	ISSUE
06.19.26	CLIENT REVIEW
08.12.26	CLIENT REVIEW
08.13.26	FOR PERMIT

This is an original design and may not be used or copied under penalty of law. Drawings, specifications, and all other instruments of service are and shall remain the physical and intellectual property of MARC O'GRADY DESIGN whether the projects for which they are created are executed or not.
© 2025-2026 MARC O'GRADY DESIGN

61	1st FLOOR	MECHANICAL ROOM	FLOORING	UTILITY CLOSET (HVAC + WH)	Optimax Performance	Optimax Performance (Bradford Honi Natural/Honey		101337228 Floor & Decor	
62	1st FLOOR	MECHANICAL ROOM	LIGHT FIXTURE	UTILITY CLOSET (HVAC + WH)	Nuvo	LED 2 foot with Motion Sensor	White	65/1214	Ferguson Home
63	INTERIOR	GENERAL	WALL	WALL MATERIAL	Alexandria Moulding	Vertical Shiplap/Tongue & Groove	White (Satin/Eggshell)	405NG	Home Depot
64	INTERIOR	GENERAL	DOOR STYLE	HOLLOW CORE OR SOLID?	ELD-WEN (Standard Home Depot stor	2-Panel Square Solid Core	Primed White	JELD-WEN	Home Depot
65	INTERIOR	GENERAL	KNOB - DOORS		Atlas Marlin Knob	Atlas Marlin Knob	Matte Black		Ferguson Home
66	INTERIOR	GENERAL	TRIM - INTERIOR	BASE, DOOR, WINDOW		1x4 Base & 1x3 Casing (Square edge)	White (Semi-Gloss)		Home Depot
67	INTERIOR	GENERAL	LIGHT SWITCHES			Lutron Diva Rocker Dimmer	White	DVCL-153P-WH	Home Depot
68	INTERIOR	GENERAL	OUTLETS		Leviton	Tamper-Resistant Decorator Outlet	White	R62-05325-2WS	Home Depot
69	INTERIOR	KITCHEN	LIGHT FIXTURE	up lighting in soffet space wired to switch	WAC	InvisiLED Pro	white	LED-T24W-5-WT	Ferguson Home
70	INTERIOR	BEDROOM 1	LIGHT FIXTURE	up lighting in soffet space wired to switch	WAC	InvisiLED Pro	white	LED-T24W-5-WT	Ferguson Home
71	INTERIOR	BEDROOM 2	LIGHT FIXTURE	up lighting in soffet space wired to switch	WAC	InvisiLED Pro	white	LED-T24W-5-WT	Ferguson Home
72	INTERIOR	BEDROOM 3	LIGHT FIXTURE	up lighting in soffet space wired to switch	WAC	InvisiLED Pro	white	LED-T24W-5-WT	Ferguson Home
73	EXTERIOR	GENERAL	WINDOWS		Contractor/Architect to Advise		Andersen or Equal		
74	EXTERIOR	ENTRY	DOORS - ENTRY	Contractor/Architect to Advise	Andersen or Equal				
75	EXTERIOR	LIVING AREA	DOORS - PATIO		Contractor/Architect to Advise		Andersen or Equal		
76	EXTERIOR	KITCHEN	DOORS - PATIO	Contractor/Architect to Advise	Andersen or Equal				
77	EXTERIOR	DECK - REAR	DECKING	Contractor/Architect to Advise	5/4" x 6 Pressure Treated				



MARCOGRADY.COM
703.729.5124

ASHBURN, VA 20147
+
TRAVERSE CITY, MI 49684


ALGONKIAN CABIN RENOVATION

CABIN #10
46442 PARK CHALET PL
STERLING, VA 20165



DATE:	ISSUE
06.19.26	CLIENT REVIEW
08.12.26	CLIENT REVIEW
08.13.26	FOR PERMIT

This is an original design and may not be used or copied under penalty of law. Drawings, specifications, and all other instruments of service are and shall remain the physical and intellectual property of MARC O'GRADY DESIGN whether the projects for which they are created are executed or not.
© 2025-2026 MARC O'GRADY DESIGN

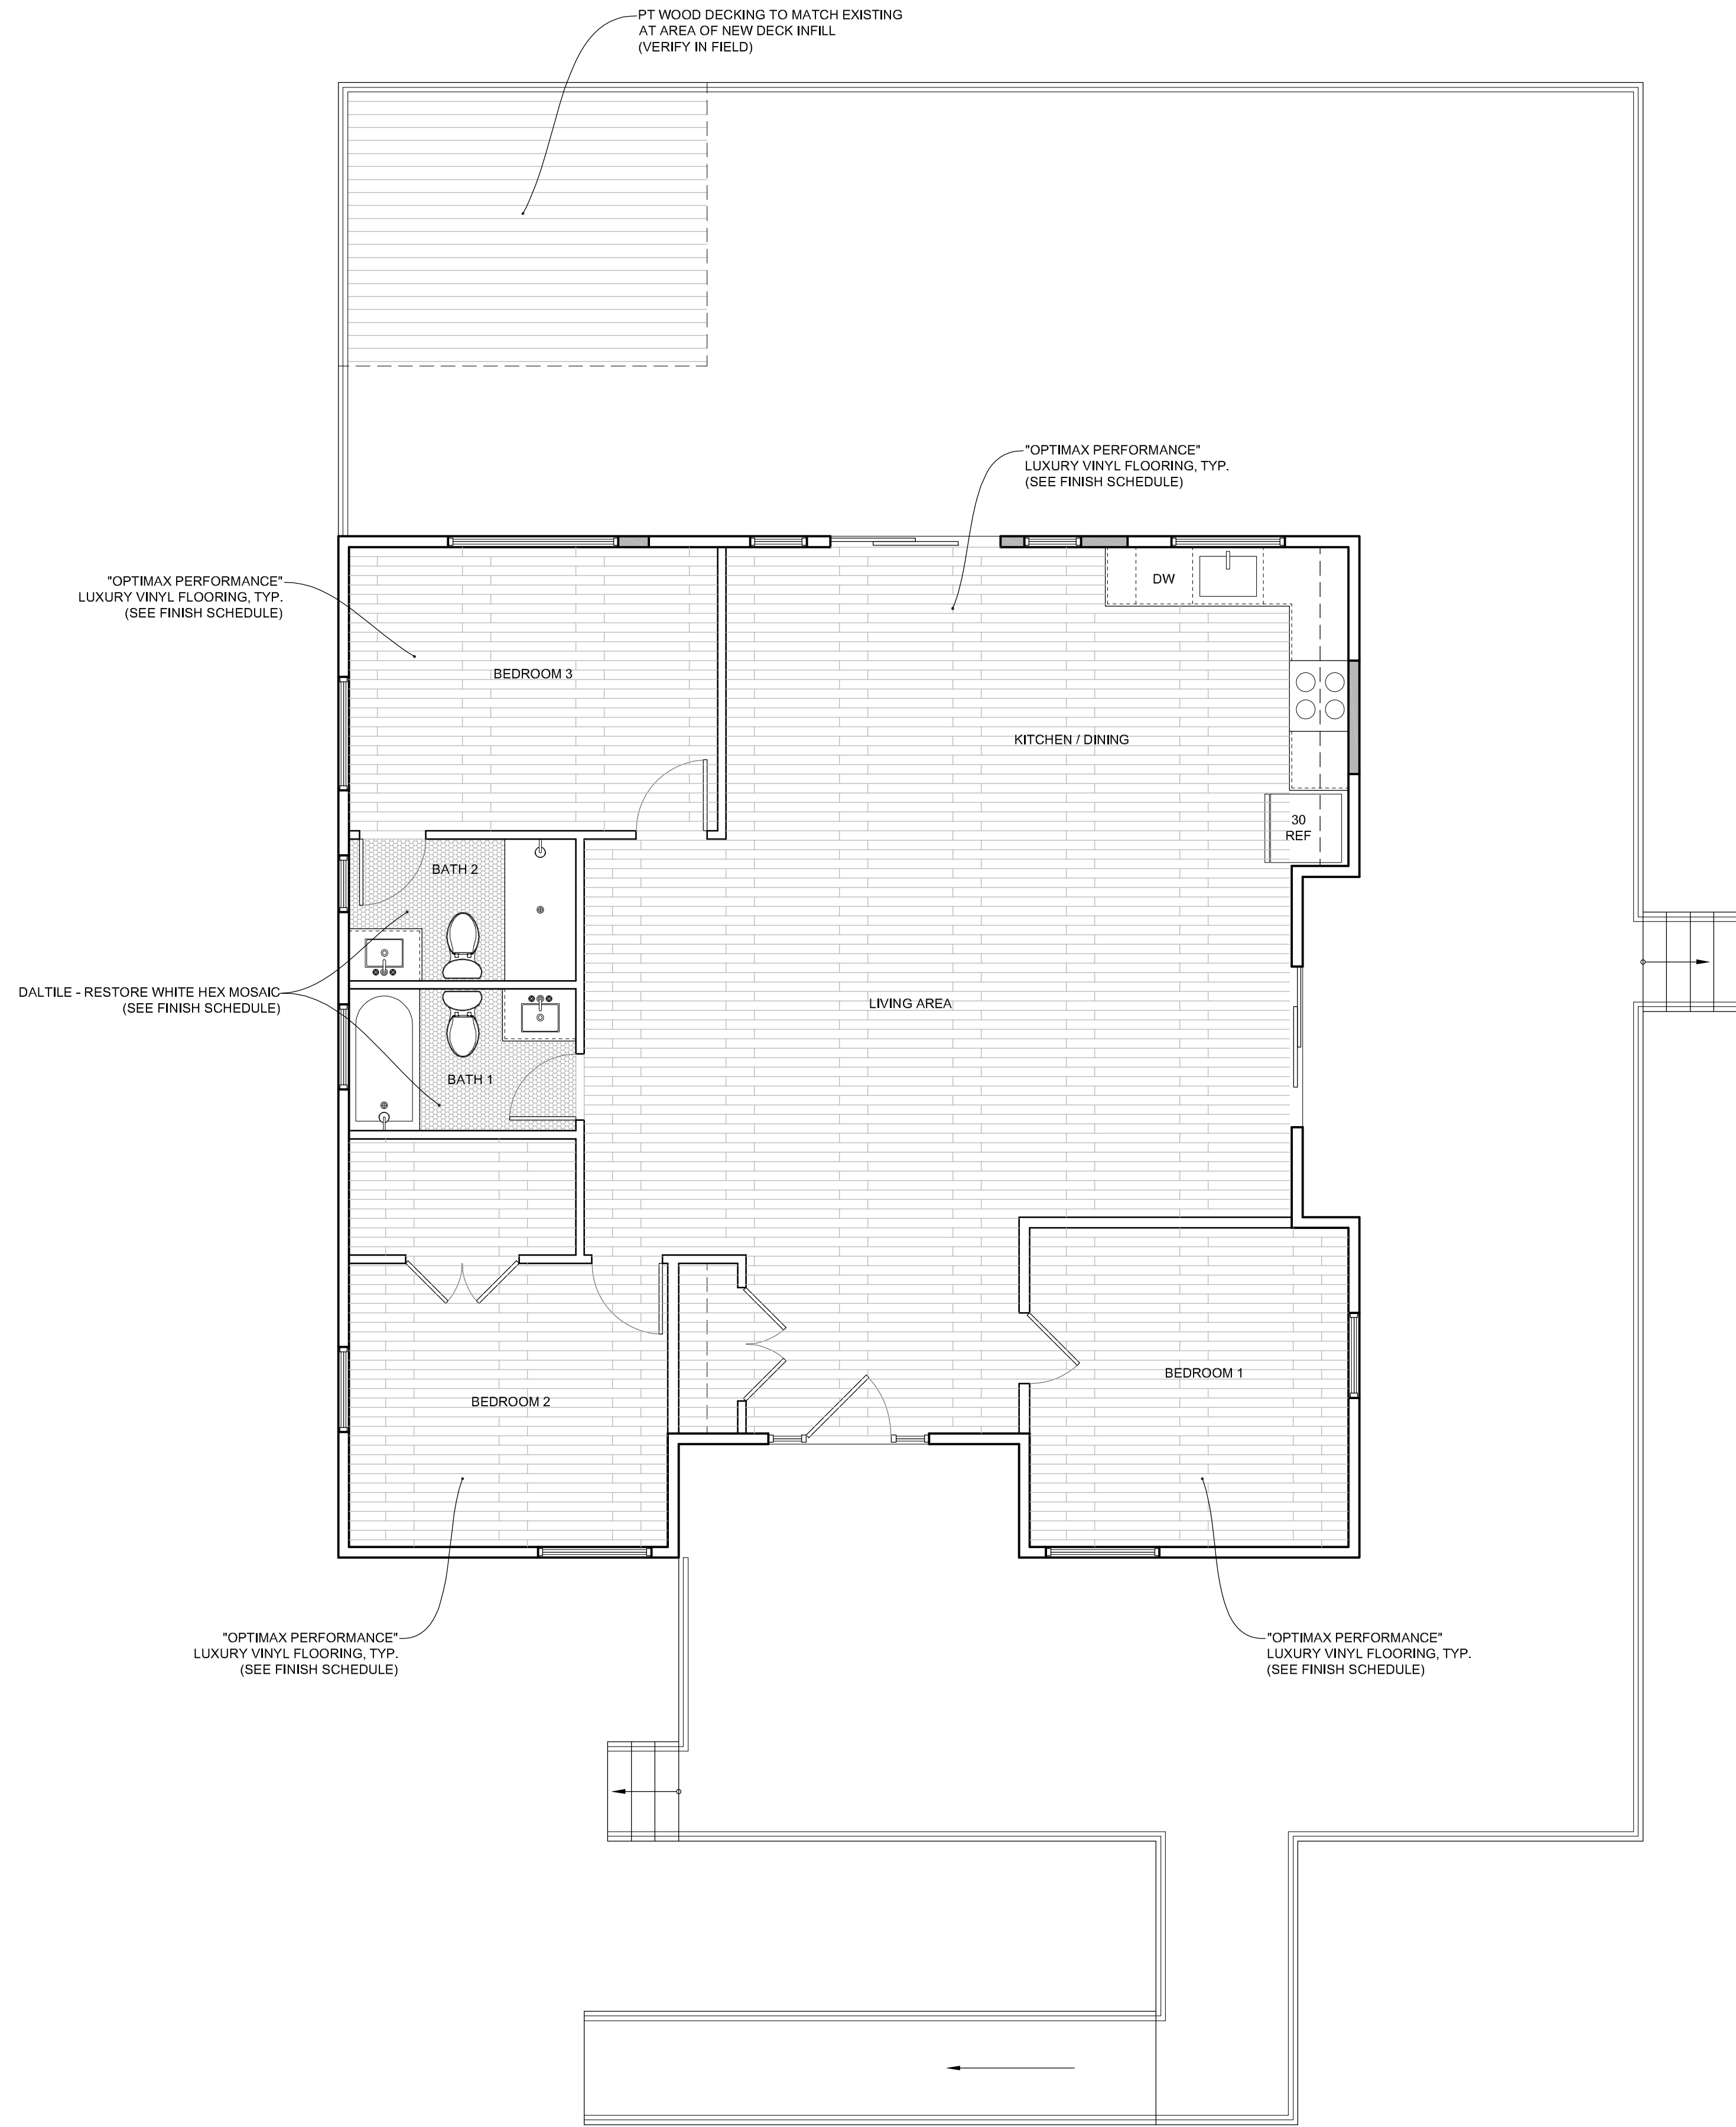

01
FINISH PLAN
1/4" = 1'-0"



MARCOGRADY.COM
703.729.5124

ASHBURN, VA 20147
+
TRAVERSE CITY, MI 49684

ALGONKIAN CABIN RENOVATION

CABIN #10
46442 PARK CHALET PL
STERLING, VA 20165



DATE	ISSUE
06.19.26	CLIENT REVIEW
08.12.26	CLIENT REVIEW
08.13.26	FOR PERMIT

This is an original design and may not be used or copied under penalty of law. Drawings, specifications, and all other instruments of service are and shall remain the physical and intellectual property of MARCO O'GRADY DESIGN whether the projects for which they are created are executed or not.

© 2025-2026 MARCO O'GRADY DESIGN

A9



MARCOGRADY.COM
703.729.5124

ASHBURN, VA 20147
+
TRAVERSE CITY, MI 49684


ALGONKIAN CABIN RENOVATION
CABIN #10
46442 PARK CHALET PL
STERLING, VA 20165



DATE:	ISSUE:
06.19.26	CLIENT REVIEW
08.12.26	CLIENT REVIEW
08.13.26	FOR PERMIT

This is an original design and may not be used or copied under penalty of law. Drawings, specifications, and all other instruments of service are and shall remain the physical and intellectual property of MARCO O'GRADY DESIGN whether the projects for which they are created are executed or not.
© 2025-2026 MARC O'GRADY DESIGN

E1

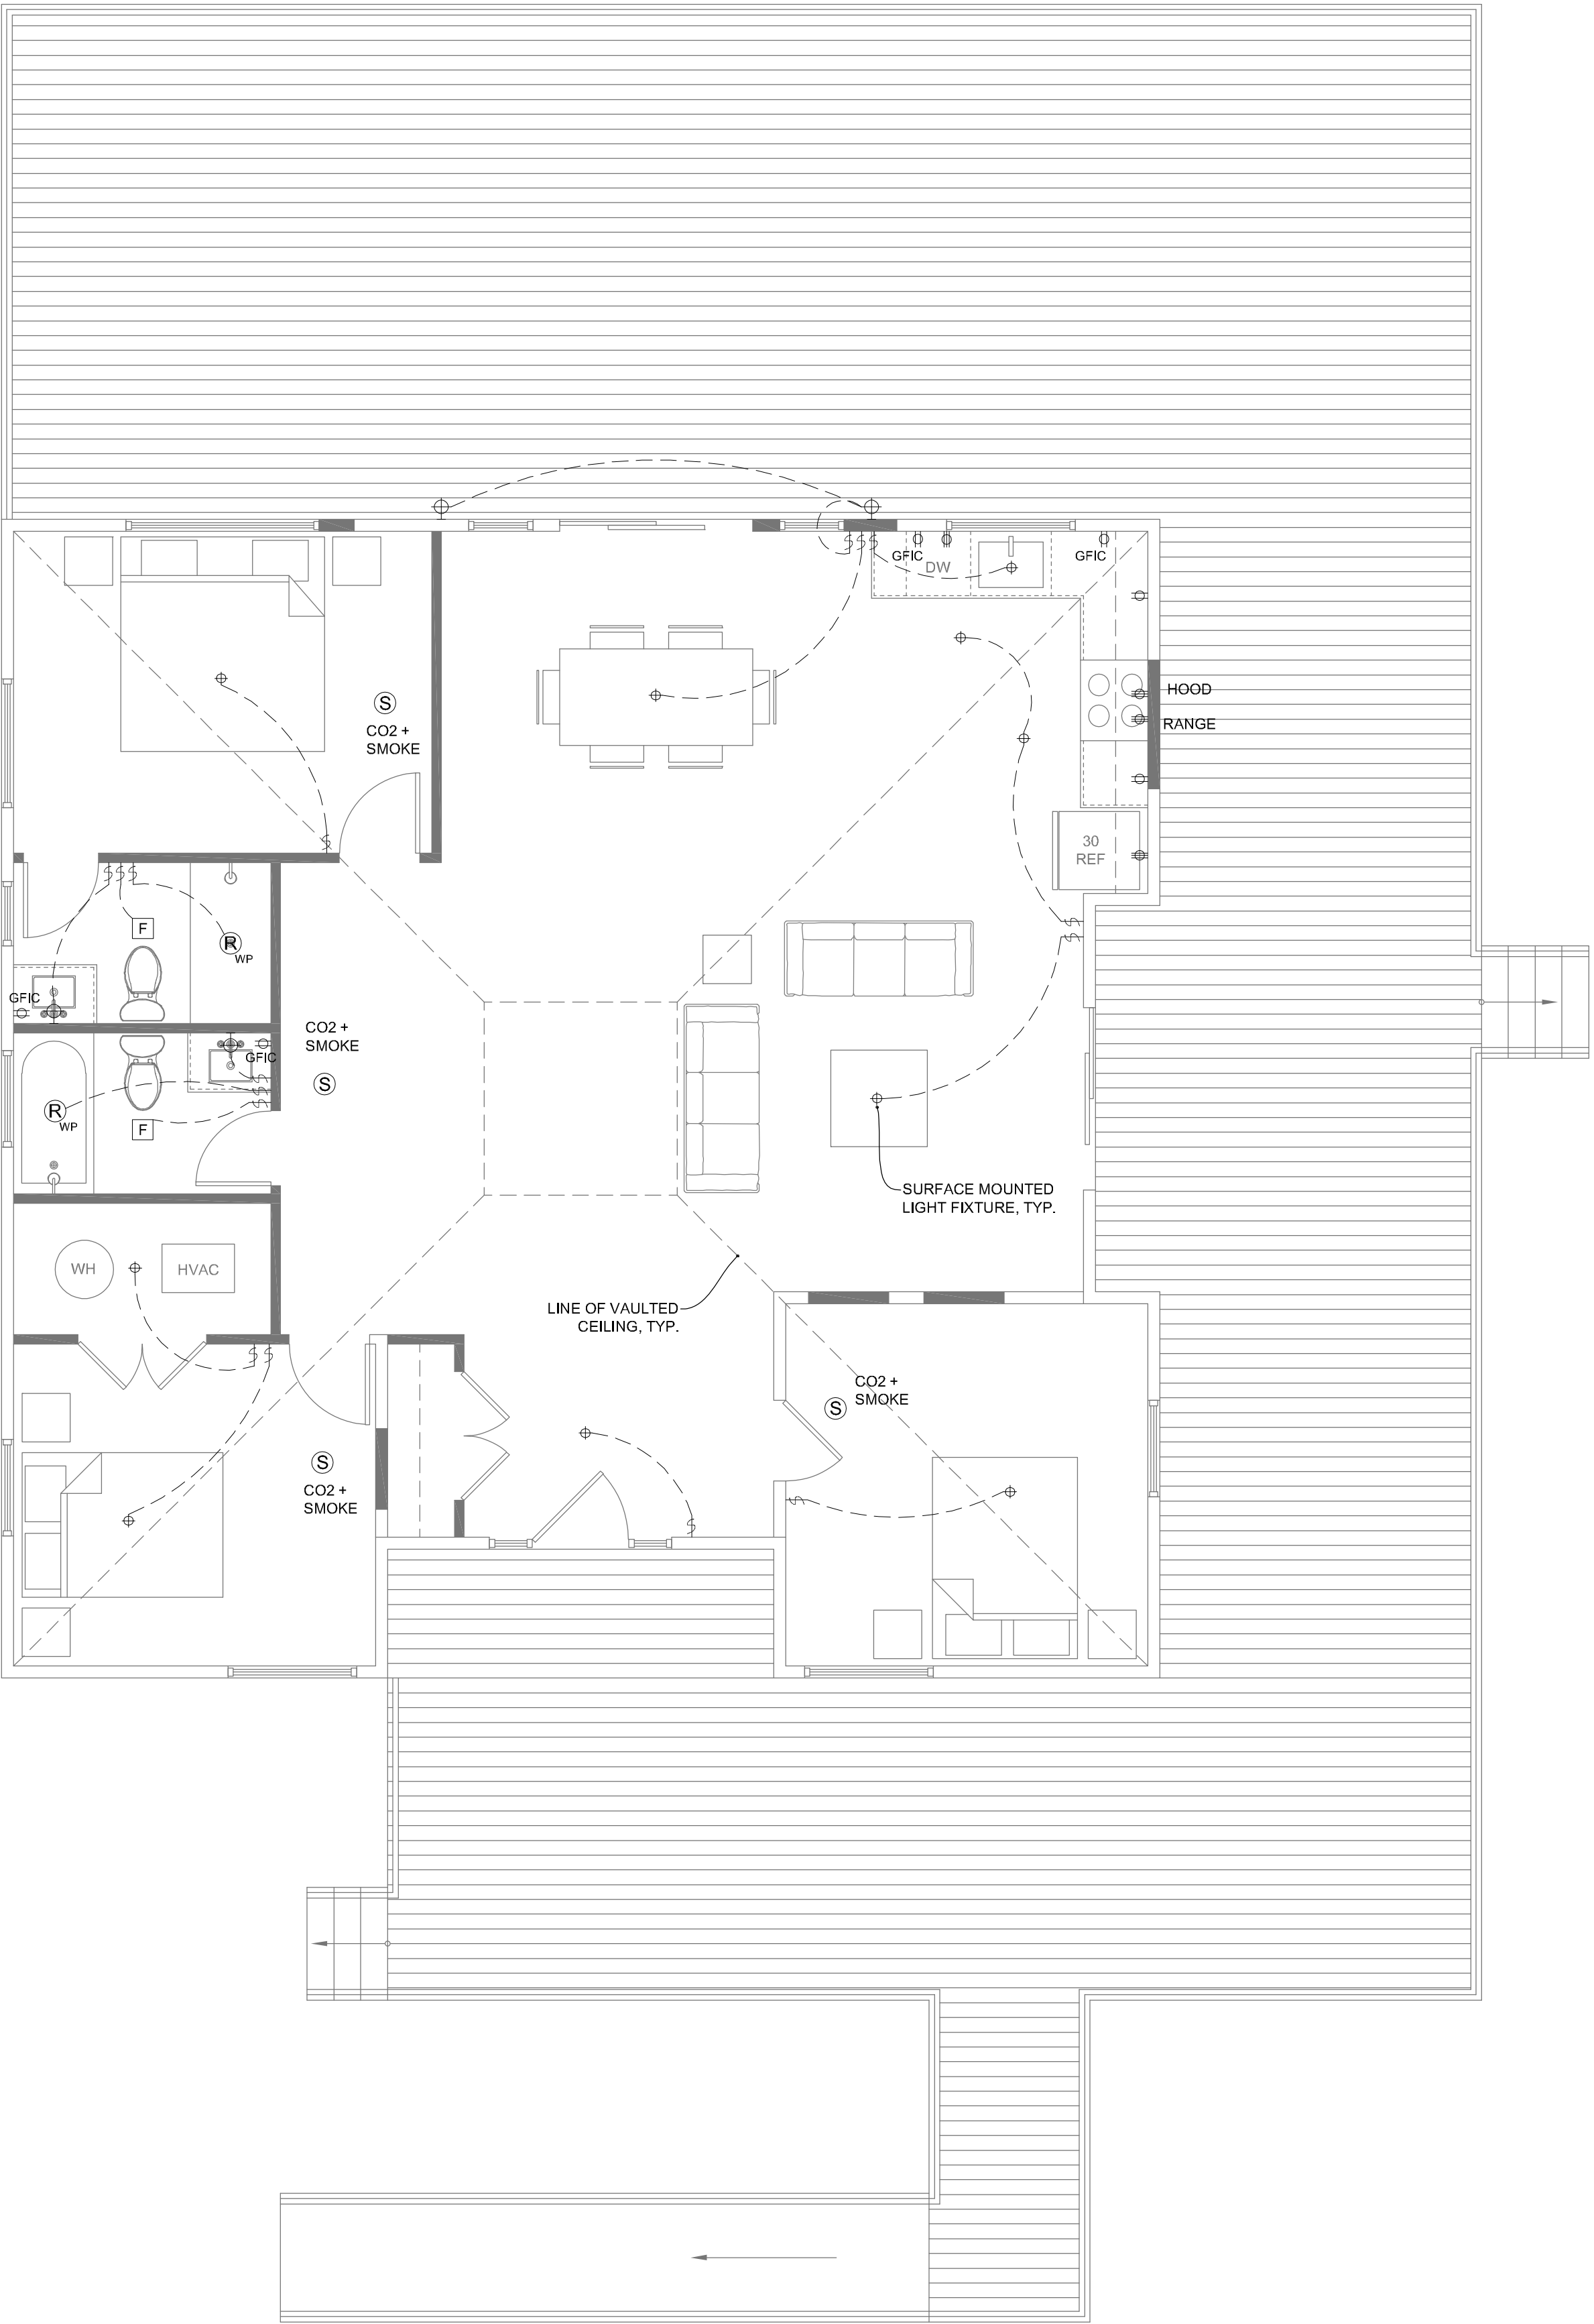

E1
FIRST FLOOR ELECTRICAL PLAN
1/4" = 1'-0"

- ELECTRICAL NOTES:**
1. PROVIDE MAKE-UP AIR FOR RANGE HOOD OVER 400 CFM
 2. VENT BATHROOM EXHAUST FANS TO EXTERIOR
 3. OUTLETS TO CODE
 4. VERIFY LOCATION OF ALL LIGHTING AND SWITCHES WITH HOMEOWNER PRIOR TO INSTALLATION.

NOTE:
WHEN IN CONSTRUCTION PHASE VERIFY ALL LIGHTING/ELECTRICAL LOCATIONS PRIOR TO INSTALLATION. IF FIXTURES CAN NOT BE INSTALLED ACCORDING TO DRAWINGS, REVIEW NEW LOCATIONS WITH CONTRACTOR AND HOMEOWNER FOR FINAL APPROVAL.

- ELECTRICAL SYMBOL KEY:**
- ALL ITEMS ARE CONTRACTOR PROVIDED UNLESS NOTED OTHERWISE
- SINGLE POLE SWITCH
 - SINGLE POLE DIMMER SWITCH
 - 3-WAY SWITCH
 - STANDARD DUPLEX OUTLET
 - GROUND FAULT INTERRUPTER CIRCUIT
 - DEDICATED CIRCUIT
 - 5" RECESSED LIGHT
 - WATER-PROOF RECESSED LIGHT
 - DIRECTIONAL RECESSED LIGHT
 - SURFACE MOUNTED LIGHT FIXTURE
 - WALL MOUNTED LIGHT FIXTURE
 - CEILING FAN
 - UNDERCABINET LIGHT
 - INCANDESCENT LIGHT
 - CAT-5 DATA OUTLET
 - CABLE TV OUTLET
 - TELEPHONE OUTLET
 - EXHAUST FAN
 - SMOKE DETECTOR- HARDWIRED, INTERCONNECTED + BATTERY BACK-UP
 - GARBAGE DISPOSAL

STRUCTURAL NOTES

General Notes

1.

All work and materials to comply with the requirements of the IRC 2021 Edition as amended by LOUDOUN COUNTY, VA.

2.

Codes: the following design standards are applicable by reference:
ACI 530-13/ASCE 5-99 Building Code Requirements for Masonry Structures.
AITC - Timber Construction Manual - fifth Ed.
ACI 318-14 Building Code Requirements for Reinforced Concrete
AISC - Manual of Steel Construction Ninth Ed.

3.

Foundations: footings, underpinning and slab on grades are designed to bear on native soil with an allowable bearing pressure of 1500 psf
A qualified soil-bearing inspector prior to placement of concrete shall verify all bearing values.

4.

Structural:
A. All structural steel, including detail material shall conform to ASTM A572 Fy = 50ksi, U.N.O.
B. All structural tubing shall conform to ASTM A500, grd. B
C. All steel pipe shall be ASTM A53, type E or S, grade B.
D. All welders shop and field, shall be certified. Use E70xx electrodes only.
E. All steel exposed to weather and exterior masonry support shall receive one shop coat of corrsion-inhibiting primer.
F. Detailing, fabrication and erection shall be in accordance with AISC.
G. All exterior structural steel shall receive rust preventative paint.
H. Connections; All beam connections shall be simple shear connections, U.N.O. Where no reaction is provided, the beam shall be assumed to carry 120% of the allowable uniform load in kips for beams laterally supported, as given in the AISC steel construction manual. Except as noted, all fasteners shall be 3/4" diameter ASTM A325 bolts, designed to act in bearing type connections with threads included.

5.

Lumber:
A. Lumber shall be SPF #2 with a min. Fb = 875psi Min. Fv = 135psi and min. E = 1,400,000psi.
B. LVL and PSL shall have a min. Fb = 2850psi; Fv = 285psi; E = 2,000,000psi.
C. Floor decking shall be 3/4" APA rated decking. Roof decking shall be 5/8" APA rated decking. Wall sheathing shall be 7/16" APA rated sheathing. Glue and nail roof and floor decking to joists and rafters.
D. Provide double joists joist under all walls that run parallel to floor framing.
E. Nail all multiple members together per the manufacturer's recommendations and at a minimum use 2-10d nails at 6" O.C. staggered. Glue all multiple studs together and stagger sides that nails are driven from.
F. Provide bridging at center of all joist spans exceeding 8'-0" and at 1/3 points of all joist spans exceeding 16'-0".
G. Provide solid blocking at all bearing points on top of walls or beams.
H. Provide solid blocking below all wood posts.
I. All posts shall have Simpson Cap an Base plates typ.
J. All joists shall have Simpson Hangers where applicable.
K. All lumber in contact with masonry or concrete or within 8" of soil shall be reassure treated. All lumber to conform to IRC R319 for protection against corrosion and termite damage.
L. Wood lintels shall be as follows;
Opening <3'-6" - 2-2x6
3'-6" < opening <5'-6" - 2-2x8
5'-6" < opening <7'-0" - 2-2x10
Greater than 7'-0" - See plans

6.

Fasteners:
A. All prefabricated angles, bearing plates, and joist hangers shall be installed per the manufacturers recommendations.
B. Epoxy Bolts shall be Simpson SET. Follow the manufacturers recommendations for setting epoxy bolts.
C. Expansion bolts shall be rawl power studs.

7.

Masonry:
A. Masonry construction shall be in conformance with the applicable sections of aci 530-13/ASCE5-99, "Specifications for Masonry Structures."
B. Concrete masonry units shall be hollow load bearing units (ASTM C90) grade n-1 with a net strength of 2000psi and F'm -1500psi.
C. All joints to be filled solid with mortar.
D. Mortar to comply with ASTM C270 (type M or S).

8.

Cast in place concrete:
A. Concrete construction shall be in conformance with the applicable sections of ACI 318-14, "Part 3 - Construction Requirements."
B. Concrete shall have a minimum compressive strength at 28 days of 4,000psi, UNO (unless noted otherwise).
C. All concrete shall be placed with a slump of 4" (+ 1/2")
D. All concrete shall be normal weight, UNO.
E. Concrete cover for reinforcement shall be:
Columns and beams 1 1/2"
Slabs 3/4"
Footings 3"

9.

Reinforcement:
A. Reinforcing bars shall be deformed bars conforming to ASTM A615, grade 60 (fy = 60ksi)
B. Welded wire fabric (wvf) shall conform to ASTM a185. Lap edges of wire fabric at least 6" in each direction.

10.

Dimensions: The contractor shall field verify all dimensions prior to fabrication of structural components.

11.

Coordination: The contractor shall coordinate all sleeves, duct openings and holes between trades. Any conduits or pipes embedded in concrete must be in accordance with ACI 318-95, chapter 6. Where sleeves are closely spaced in a group, the group shall be treated as an opening and reinforced accordingly. Submit drawings showing all opening sizes and locations for the approval by the structural engineer.

LOADS:

LIVE LOADS

FLOOR: 40PSF

DECK: 40PSF

BEDROOM 30PSF

ROOF: 30PSF

ATTIC: 20PSF

BALCONY: 60PSF

WIND LOADS

BASIC WIND SPEED: 90 MPH

WIND LOAD IMPORTANCE FACTOR: 1.0

WIND EXPOSURE FACTOR: B

SNOW LOADS:

GROUND SNOW LOAD (PG): 30PSF

SEISMIC DESIGN DATA

SEISMIC DESIGN CATEGORY: B

01
FRAMING PLAN
1/4" = 1'-0"

GENERAL NOTES:

ON-SITE VERIFICATION OF ALL DIMENSIONS AND CONDITIONS SHALL BE THE RESPONSIBILITY OF THE GENERAL CONTRACTOR AND HIS/HER SUBCONTRACTORS.

NOTED DIMENSIONS TAKE PRECEDENCE OVER SCALE. DO NOT SCALE DRAWINGS.

THE GENERAL NOTES AND TYPICAL DETAILS APPLY THROUGHOUT THE JOB UNLESS OTHERWISE NOTED OR SHOWN.

DISCREPANCIES: THE CONTRACTOR SHALL COMPARE AND COORDINATE ALL DRAWINGS; WHEN IN THE OPINION OF THE CONTRACTOR, A DISCREPANCY EXISTS HE/SHE SHALL PROMPTLY REPORT IT TO THE ARCHITECT AND/OR DESIGNER FOR PROPER ADJUSTMENT BEFORE PROCEEDING WITH THE WORK.

m

MARCO'GRADY

DESIGN

MARCOGRADY.COM

703.729.5124

ASHBURN, VA 20147

+

TRAVERSE CITY, MI 49684

ALGONKIAN CABIN RENOVATION

CABIN #10

46442 PARK CHALET PL

STERLING, VA 20165

CERTIFIED PROFESSIONAL BUILDING DESIGNER

NATIONAL COUNCIL OF BUILDING DESIGNERS

MARCO O'GRADY

47-167

Professional Engineer

COMMONWEALTH OF VIRGINIA

SMAIL RUAB HANIEH

Lic. No. 29424

Professional Engineer

August 13, 2026

DATE:	ISSUE:
06.19.26	CLIENT REVIEW
08.12.26	CLIENT REVIEW
08.13.26	FOR PERMIT

This is an original design and may not be used or copied under penalty of law. Drawings, specifications, and all other instruments of service are and shall remain the physical and intellectual property of MARCO O'GRADY DESIGN whether the projects for which they are created are executed or not.

© 2025-2026 MARCO O'GRADY DESIGN

S1



Virginia Practical Wall Bracing Worksheet


per 2018 Virginia Residential Code R602.12

Ultimate Wind Speed (mph)		115 (90)								
Rectangle Size (ft)		Front/Rear: 36		Left/Right: 36		Aspect Ratio:		PASS		
Rectangle Side		Front		Rear		Left		Right		
Number of Floors Above		0		0		0		0		
Eave-to-Ridge Height (ft)		5.5		5.5		5.5		5.5		
Exterior BWP Material		Wood Structural Panels		Wood Structural Panels		Wood Structural Panels		Wood Structural Panels		
Tabular Requirement (ft)		5.60		5.60		5.60		5.60		
Adjustments	Exposure	B	1.00	B	1.00	B	1.00	B	1.00	
	Wall Ht. (ft)	8.00	0.90	8.00	0.90	8.00	0.90	8.00	0.90	
	Omit Interior Finish?	No	1.00	No	1.00	No	1.00	No	1.00	
	Fasteners @ 4" o.c.?	No	1.00	No	1.00	No	1.00	No	1.00	
Required BWP Length (ft)		5.04		5.04		5.04		5.04		
Required BWP Length from Common Rectangle Side										
Total Required BWP Length (ft)		5.04		5.04		5.04		5.04		
Actual BWPs	Contributing Length (ft) CS-PF=1.5xactual PFG=1.5xactual PFH=4' ABW=4'	BWP	Location	Length	Location	Length	Location	Length	Location	Length
		1	Exterior	7.00	Exterior	3.75	Exterior	5.00	Exterior	12.00
		2	Exterior	3.00	Exterior	4.50	Exterior	2.25	Exterior	3.00
		3	Exterior	3.00	Exterior	3.00	Exterior	3.25	Exterior	3.00
		4	Exterior	7.00	Exterior	2.50	Exterior	9.00	Exterior	3.25
		5					Exterior	4.50	Exterior	5.50
		6								
		7								
Actual BWP Length (ft)		20.00		13.75		24.00		26.75		
Actual ≥ Required?		Pass		Pass		Pass		Pass		
BWPs ≤ 20' Apart?		Yes		Yes		Yes		Yes		
BWP within 12' of Corners?		Yes		Yes		Yes		Yes		
Compliant Number of BWPs		Yes		Yes		Yes		Yes		
BWL Compliance		Pass		Pass		Pass		Pass		

To report an error or bug, call 703-324-1842, TTY 711

A Fairfax County, Virginia Publication

Practial VRC2018 - 8/6/2021

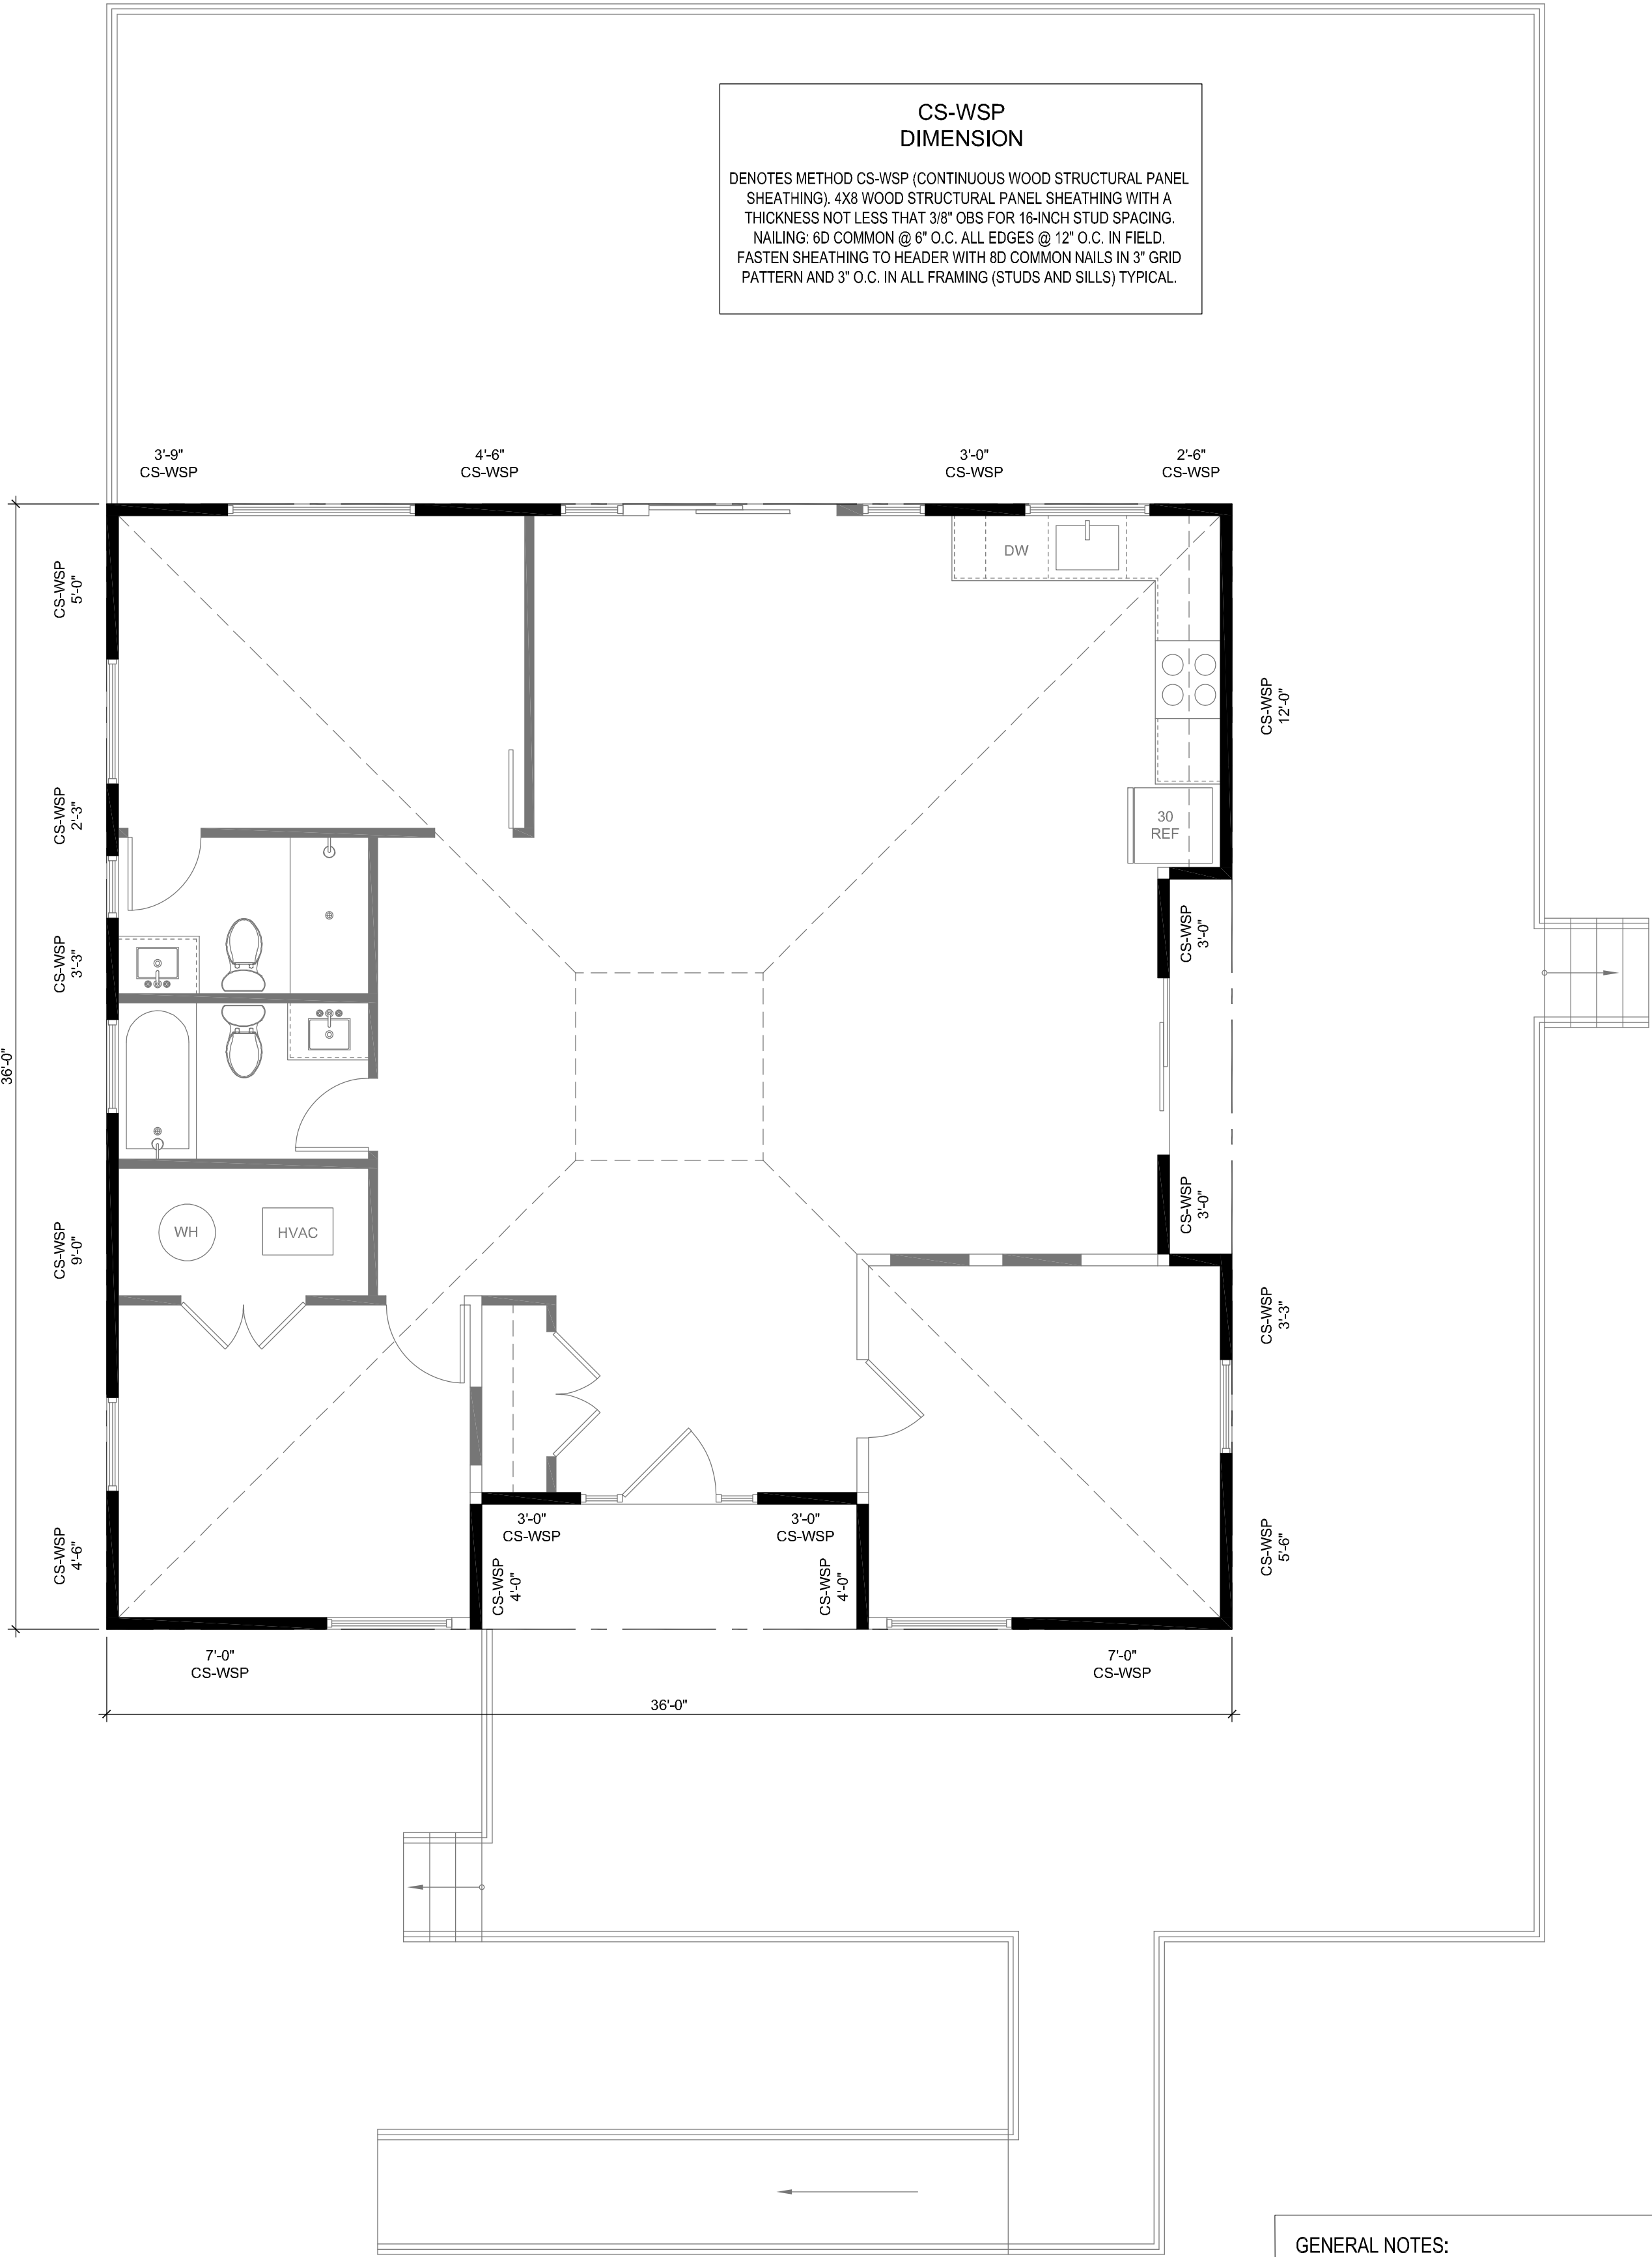

CS-WSP
DIMENSION

DENOTES METHOD CS-WSP (CONTINUOUS WOOD STRUCTURAL PANEL SHEATHING); 4X8 WOOD STRUCTURAL PANEL SHEATHING WITH A THICKNESS NOT LESS THAN 3/8" OBS FOR 16-INCH STUD SPACING. NAILING: 6D COMMON @ 6" O.C. ALL EDGES @ 12" O.C. IN FIELD. FASTEN SHEATHING TO HEADER WITH 8D COMMON NAILS IN 3" GRID PATTERN AND 3" O.C. IN ALL FRAMING (STUDS AND SILLS) TYPICAL.

WB1
WALL BRACING PLAN
1/4" = 1'-0"

- GENERAL NOTES:
- ON-SITE VERIFICATION OF ALL DIMENSIONS AND CONDITIONS SHALL BE THE RESPONSIBILITY OF THE GENERAL CONTRACTOR AND HIS/HER SUBCONTRACTORS.
 - NOTED DIMENSIONS TAKE PRECEDENCE OVER SCALE. DO NOT SCALE DRAWINGS.
 - THE GENERAL NOTES AND TYPICAL DETAILS APPLY THROUGHOUT THE JOB UNLESS OTHERWISE NOTED OR SHOWN.
 - DISCREPANCIES: THE CONTRACTOR SHALL COMPARE AND COORDINATE ALL DRAWINGS; WHEN IN THE OPINION OF THE CONTRACTOR, A DISCREPANCY EXISTS HE/SHE SHALL PROMPTLY REPORT IT TO THE ARCHITECT AND/OR DESIGNER FOR PROPER ADJUSTMENT BEFORE PROCEEDING WITH THE WORK.



MARCOGRADY.COM
703.729.5124

ASHBURN, VA 20147
+
TRAVERSE CITY, MI 49684


ALGONKIAN CABIN RENOVATION
CABIN #10
46442 PARK CHALET PL
STERLING, VA 20165



DATE	ISSUE
06.19.26	CLIENT REVIEW
08.12.26	CLIENT REVIEW
08.13.26	FOR PERMIT

This is an original design and may not be used or copied under penalty of law. Drawings, specifications, and all other instruments of service are and shall remain the physical and intellectual property of MARC O'GRADY DESIGN whether the projects for which they are created are executed or not.
© 2025-2026 MARC O'GRADY DESIGN

NOTE:
CARBON MONOXIDE PROTECTION SHALL BE PROVIDED WITHIN 10 FEET OF EACH ROOM USED FOR SLEEPING PURPOSES PER REQUIREMENTS DESCRIBED IN THE STATE STATUTES 9B-3.0472.

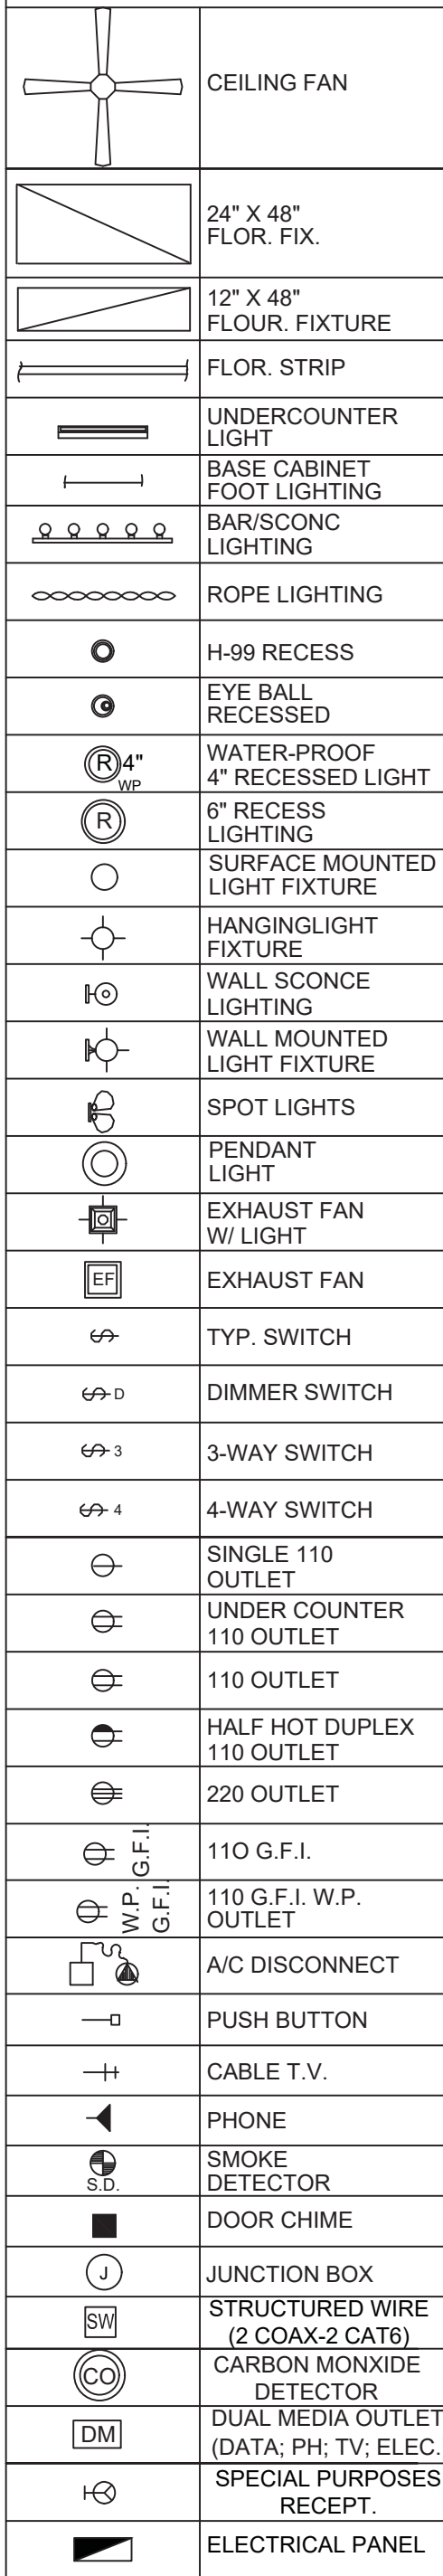

- | | | | |
|----|--|----|---|
| | MOUNT RECEPTACLE WITHIN 12" OF COUNTERTOP. | 14 | ELECTRICAL CONTRACTOR TO PROVIDE (1) LIGHT, (1)SWITCH AND (1) RECEPT. BY ATTIC ACCESS USING THE LOCAL CIRCUIT |
| 2 | MOUNT DEVICE HORIZONTALLY IN COUNTER BACKSPLASH. COORDINATE EXACT MOUNTING HEIGHT WITH ARCHITECT PRIOR TO ROUGH-IN. | 15 | WALL MOUNTED ICE MACHINE OUTLET TO BE MOUNTED IN AN ACCESSIBLE LOCATION. COORDINATE LOCATION AND REQUIREMENTS WITH SUPPLIER/INSTALLER. |
| 3 | WALL MOUNTED OUTLET FOR WATER HEATER REODR PUMP. COORDINATE EXACT LOCATION WITH SUPPLIER/INSTALLER. | 16 | MOUNT DEVICE(S) ABOVE FIRE PLACE. COORDINATE MOUNTING HEIGHT WITH ARCHITECT PRIOR TO ROUGH-IN |
| 4 | PROVIDE DISCONNECT FOR WATER HEATER. COORDINATE EXACT LOCATION WITH SUPPLIER/INSTALLER | 17 | WALL MOUNTED ICE MACHINE OUTLET TO BE MOUNTED IN AN ACCESSIBLE LOCATION. COORDINATE LOCATION AND REQUIREMENTS WITH SUPPLIER/INSTALLER |
| 5 | WALL MOUNTED WASHING MACHINE OUTLET. COORDINATE LOCATION AND REQUIREMENTS WITH SUPPLIER/INSTALLER | 18 | RECESSED FLOOR BOX SUITABLE FOR CONCRETE FLOORS WITH DEVICES AS SHOWN. COORDINATE EXACT LOCATION AND REQUIREMENTS WITH OWNER. PROVIDE ACCESSORIES AS REQUIRED. SHALL BE HUBBELL OFB2G SERIES WITH 6" OR 8" BRUSHED ALUMINUM COVER OR APPROVED EQUIVALENT. COORDINATE COVER AND FINISHES WITH ARCHITECT/OWNER PRIOR TO ROUGH-IN. |
| 6 | WALL MOUNTED DRYER MACHINE OUTLET. COORDINATE LOCATION AND REQUIREMENTS WITH SUPPLIER/INSTALLER. | 19 | CEILING MOUNTED OUTLET FOR GARAGE OPENER. COORDINATE EXACT LOCATION WITH SUPPLIER/INSTALLER. |
| 7 | GARBAGE DISPOSAL OUTLET MOUNTED UNDER SINK, CONTROLLED BY SWITCH ON. COORDINATE LOCATION AND REQUIREMENTS WITH SUPPLIER/INSTALLER | 20 | PROVIDE JUNCTION BOX FOR MOTORIZED SHADES. VERIFY AND COORDINATE EXACT LOCATIONS AND REQUIREMENTS WITH SYSTEM SUPPLIER/INSTALLER |
| 8 | WALL MOUNTED DISHWASHER OUTLET. COORDINATE LOCATION AND REQUIREMENTS WITH SUPPLIER/INSTALLER. | 21 | PROVIDE JUNCTION BOX FOR MOTORIZED SCREENS. VERIFY AND COORDINATE EXACT LOCATIONS AND REQUIREMENTS WITH SYSTEM SUPPLIER/INSTALLER |
| 9 | WALL MOUNTED REFRIGERATOR/FREEZER OUTLET. COORDINATE LOCATION AND REQUIREMENTS WITH SUPPLIER/INSTALLER. | 22 | PROVIDE JUNCTION BOX FOR MOTORIZED SHUTTERS. VERIFY AND COORDINATE EXACT LOCATIONS AND REQUIREMENTS WITH SYSTEM SUPPLIER/INSTALLER. |
| 10 | JUNCTION BOX FOR HOOD. COORDINATE LOCATION AND REQUIREMENTS WITH SUPPLIER/INSTALLER. | 23 | WALL MOUNTED GENERATOR OPEN STOP SWITCH. |
| 11 | JUNCTION BOX FOR GAS APPLIANCE. COORDINATE LOCATION AND REQUIREMENTS WITH SUPPLIER/INSTALLER | 24 | WALL MOUNTED GENERATOR REMOTE ANNUNCIATOR. |
| 12 | 120V JUNCTION BOX FOR IGNITION CIRCUIT. | | |
| 13 | WALL MOUNTED UNDERCOUNTER REFRIGERATOR OUTLET TO BE MOUNTED IN AN ACCESSIBLE LOCATION. COORDINATE LOCATION AND REQUIREMENTS WITH SUPPLIER/INSTALLER. | | |

SOME KEYNOTES MAY NOT BE USED ON THIS PLAN

VOLTAGE (L-N):		120		ENCLOSURE TYPE: NEMA 1			
VOLTAGE (L-L):		240		MOUNTING: SURFACE			
PHASES, WIRES:		1 ϕ , 3 W		AIC RATING: 22000			
MINIMUM BUS CAPACITY (A):		200 A		NOTES: NEW MLO			
MAIN O.C. DEVICE (A):		200 A					

CKT NO	DESCRIPTION	TRIP AMPS	POLE	PHASE LOADS (VA)		POLE	TRIP AMPS	DESCRIPTION	CKT NO
				A	B				
1	EXTERIOR	20	1	0	0		1	BEDROOM 3	2
3	BATH 2	20	1			0	0	BATH 1	4
5	BEDROOM 2	20	1	0	0		1	ENTRY	6
7	BEDROOM 1	20	1			0	0	LIVING AREA	8
9	KITCHEN/DINING	20	1	0	1500		1	SMALL APPLIANCE 1	10
11	SMALL APPLIANCE 2	20	1			1500	1200	DISHWASHER	12
13	DISPOSAL	20	1	828	1200		1	MICROWAVE	14
15	REFRIGERATOR	20	1			1400	400	R/HOOD	16
17	SPARE	20	1	0	0		1	SPARE	18
19	SPARE	20	1			0	0	SPARE	20
21	SPARE	20	1	0	0		1	SPARE	22
23,25	RANGE	50	2			3800	2800	CU	24,26
23,25	RANGE	50	2	3800	2800		2	CU	24,26
27,29	AHU	50	2			4750	2250	WATER HEATER	28,30
27,29	AHU	50	2	4750	2250		2	WATER HEATER	28,30
31,33	SPARE	20	2			0	0	SPARE	32,34
31,33	SPARE	20	2	0	0		2	SPARE	32,34
35,37	SPARE	20	2			0	0	SPARE	36,38
35,37	SPARE	20	2	0	0		2	SPARE	36,38
39,41	SPARE	20	2			0	0	SPARE	40,42
39,41	SPARE	20	2	0	0		2	SPARE	40,42

Residential Optional Calculation

Version 2011 L

FLORIDA ENGINEERING LLC

4161 TAMiami TRAIL, UNIT 101

PORT CHARLOTTE, FL. 33990

phone: (941) 391-5980

STEP 1 Article 220.82 (B) (1),(2)

sq. ft	Description	VA
1224	General Lighting load	3,672 VA
2	Small Appliance	3,000 VA
	Laundry circuit	VA
	Gen.Lgt. Sm App & Laun. Load	6,672 VA

STEP 2 Article 220.82 (C)

Heat Pump w/ Concurrent Supplementary Heating	QTY	Total
3 ton 5,600 VA AHU 1 8. kW	1	5,600 VA
HP #2 VA AHU 2	Select	VA
HP #3 VA AHU 3	Select	VA
HP #4 VA AHU 4	Select	VA
HP #5 VA AHU 5	Select	VA

General lighting, Sm. Appl. & Laundry 6,672 VA

STEP 3 Article 220.82 (B) (3)

VA	Description	VA
4,500 VA	1 Water Heater	4,500 VA
1,400 VA	1 Refrigerator	1,400 VA
600 VA	Freezer	VA
1,200 VA	1 Dishwasher	1,200 VA
828 VA	1 Disposal	828 VA
400 VA	1 R / Hood	400 VA
1,200 VA	1 Microwave	1,200 VA
4,000 VA	Microwave	VA
340 VA	Mini Refrig	VA
400 VA	Wine Ctr	VA
5,000 VA	Insta Hot	VA
1,500 VA	Ironing Center	VA
select	Jacuzzi Tub	VA
select	Sprinkler Pump	VA
select	Well Pump	VA
select	Fountain Pump	VA
select	Elevator	VA
	Pool Equip. Panel	VA Apply Demand
	GATES	VA No Demand
	Other load	VA No Demand

Appliance Demand Load 9,528 VA

Dryer Demand Load VA

Range Demand Load 7,600 VA

Service Demand 27,855 VA

Demand Load 116 A

Neutral Demand 57 A

Min. Service Req. 125 A

Min. Feeder size 2

Min. Neutral size 6

Eq. Grding Cond. 6

Copper

Total Appliance Load 9,528 VA

STEP 4 Article 220.82 (B) (3)

Electric Clothes Dryers **VA**

STEP 5 Article 220.82 (B) (3)

Electric Ranges **7,600 W** Col C demand **7600**

or Number of appliances

☐ Check Box for Gas Range

Number of appliances **0**

Cooktop **0**

Cooktop & Oven Demand Load **0**

Col B demand

Col B demand


Col B demand

Col B demand

Col B demand

Dem Factor **0**

- * ELECTRICAL CONTRACTOR TO PROVIDE CLEARANCES FOR ELECTRICAL EQUIPMENT PER NEC110.26
- * LOW VOLTAGE AND DATA PLANS NOT INCLUDED, PROVIDED BY OTHERS.
- * COORDINATE ALL RECEPTACLES LOCATIONS/HEIGHTS WITH ARCHITECTURAL PLAN


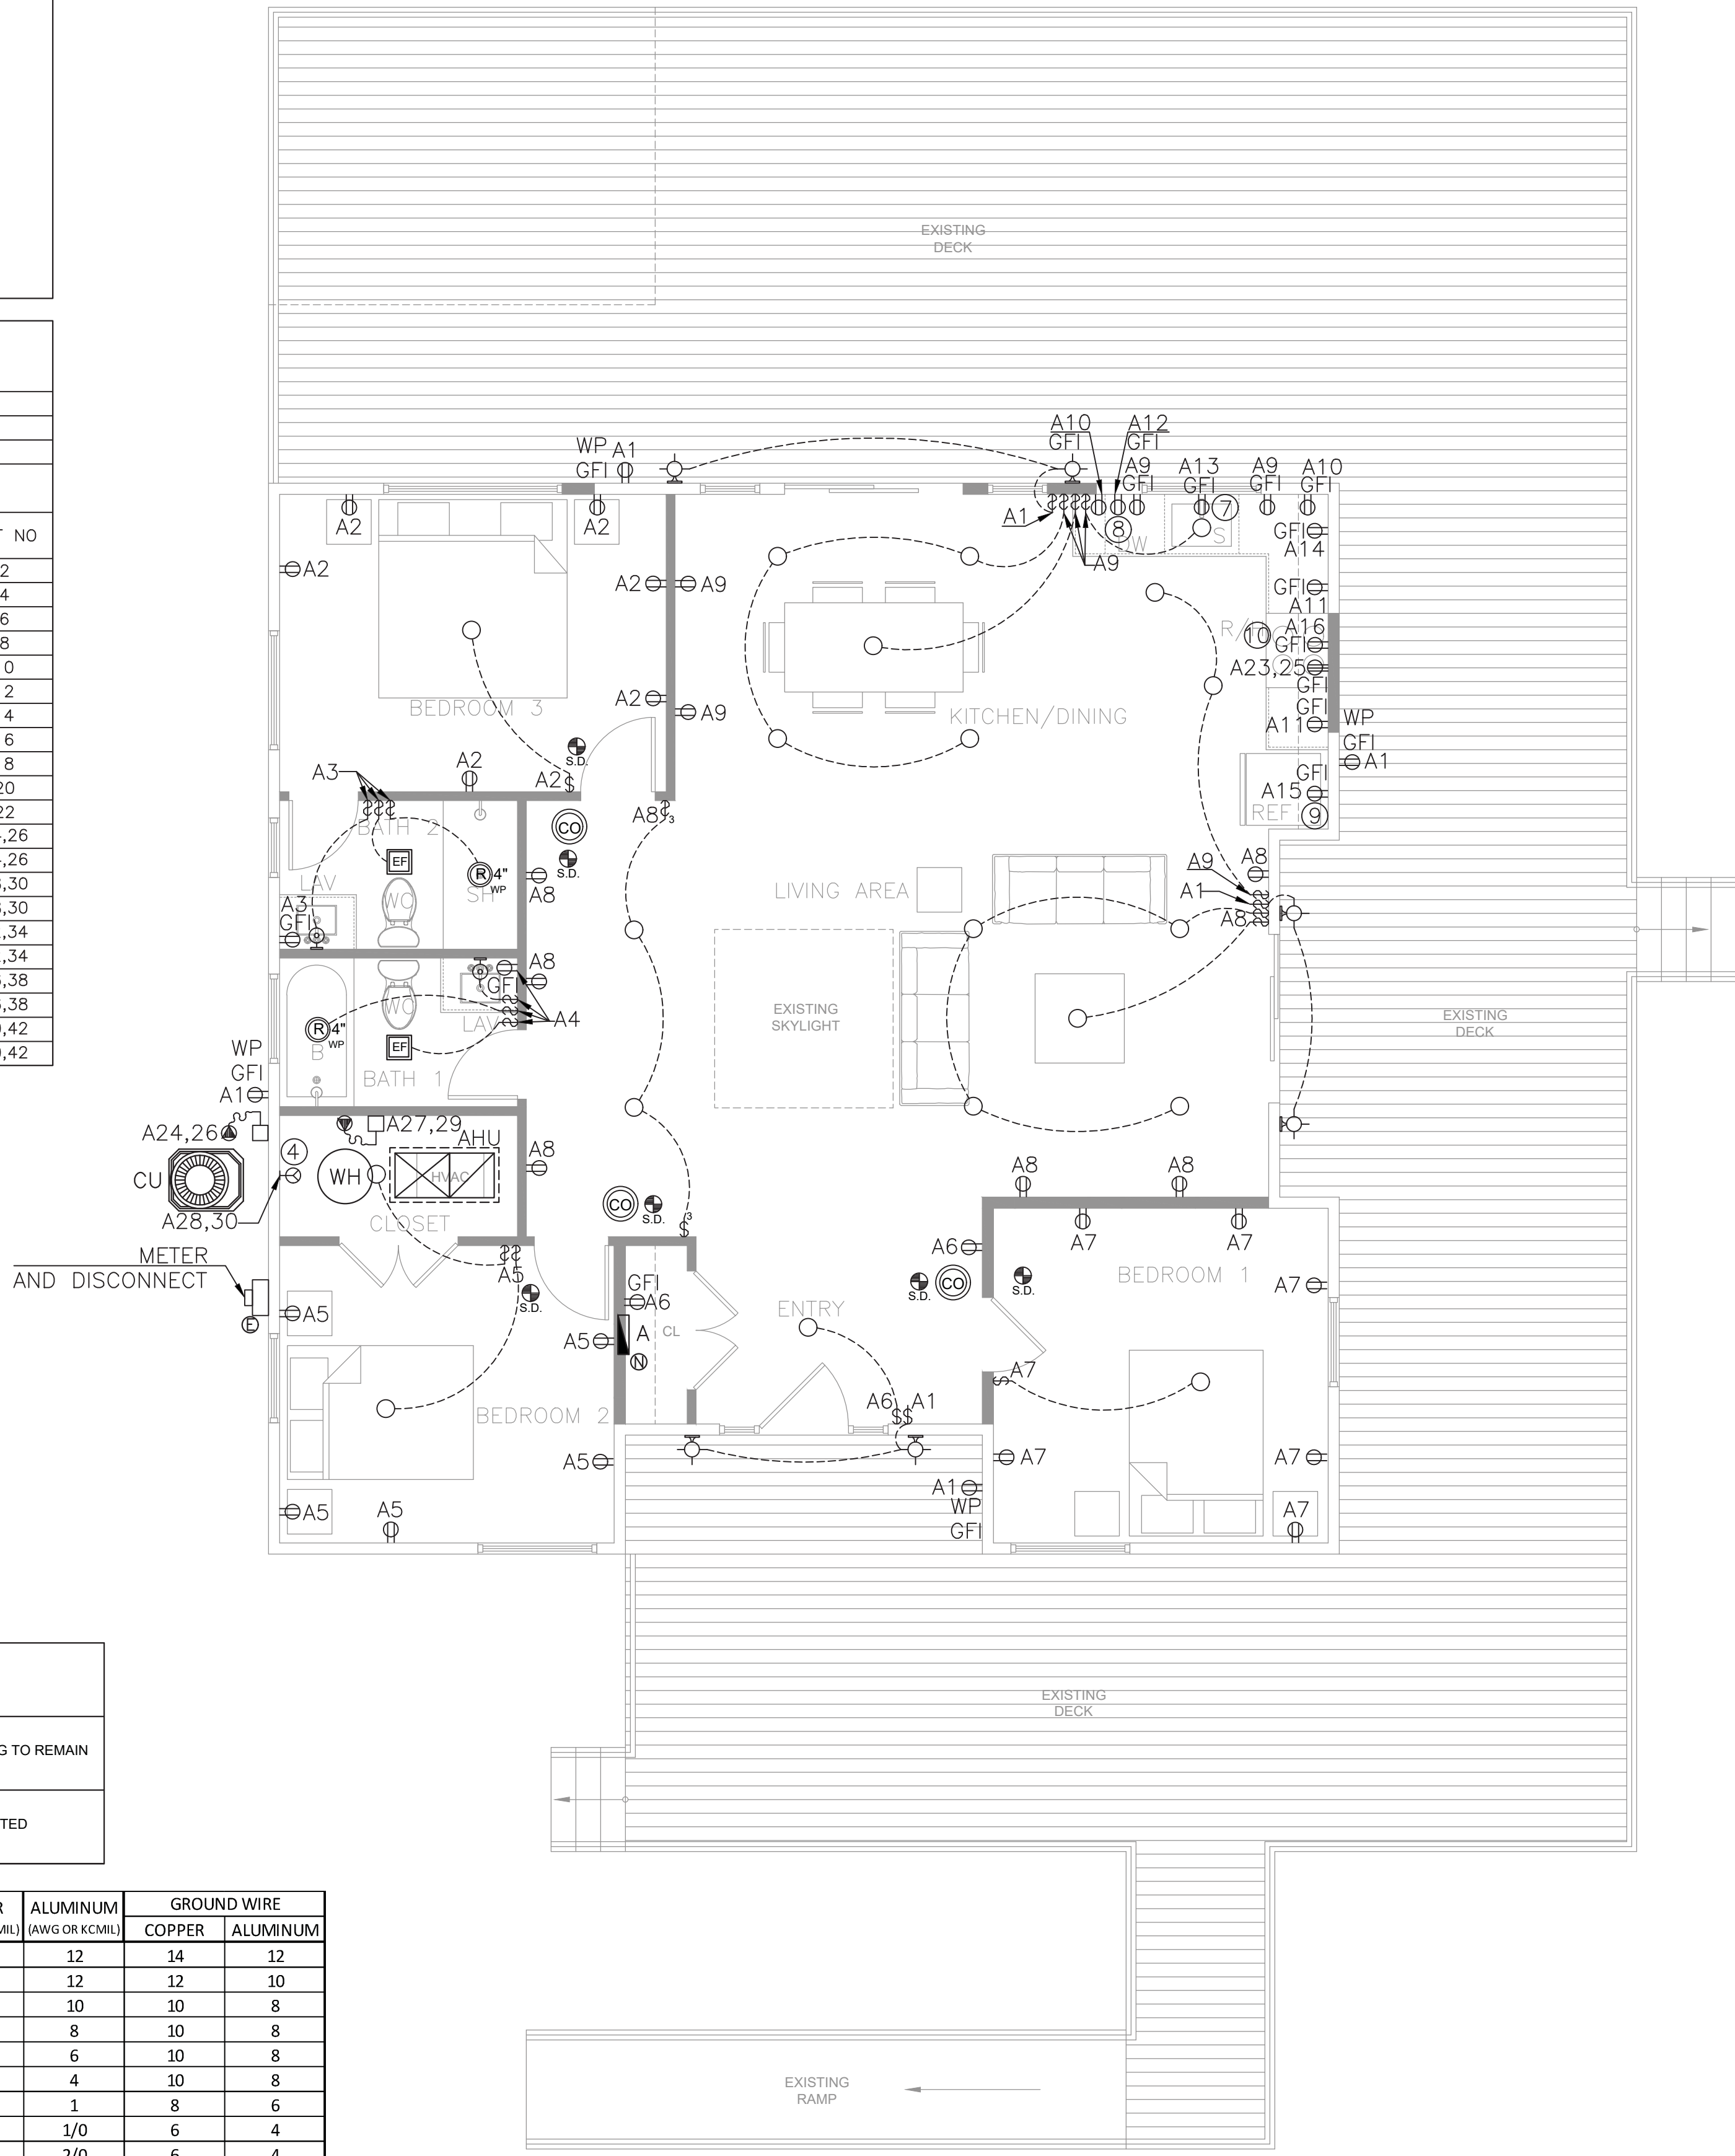

$$1/4" = 1'-0"$$


NOVA PARKS
CHALET PL, STERLING, VIRGINIA, 20165
MARC O'GRADY DESIGN

No.	Description	Date
△		
△		
△		
△		
△		

SHEET NUMBER:

E-100

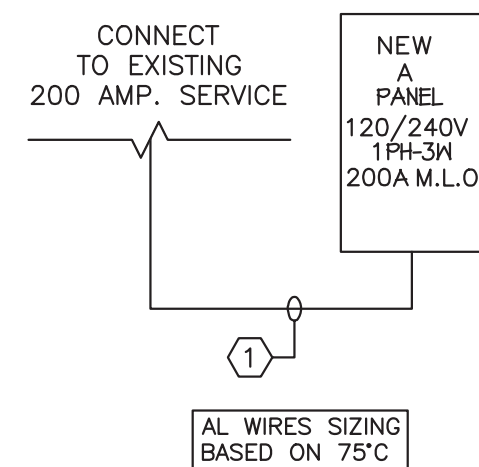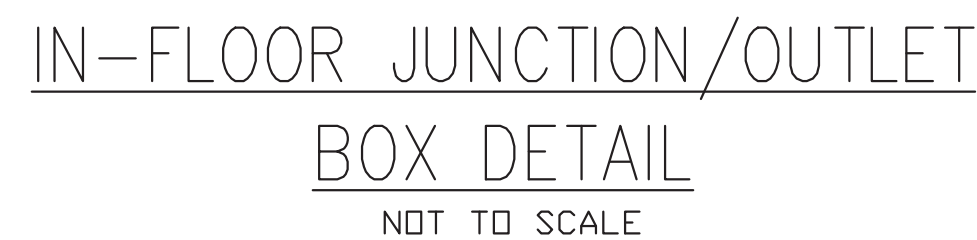PROJECT NAME
& ADDRESS:

No.	Description	Date
△		
△		
△		
△		
△		

DRAWN BY: PLC

REVISÉD BY: JPP

PROJECT NO: 26 173 78

SHEET TITLE

ELECTRICAL DETAILS

SHEET NUMBER:

ED-100

ELECTRICAL GENERAL PROVISIONS	ELECTRICAL WORK	ELECTRICAL WORK CONTINUE																		
PART 1 - GENERAL A. General Conditions and Requirements: This work is subject to the general conditions and requirements specified herein. The following codes and regulations (latest edition) govern the scope and installation of electrical work unless more stringent requirements are indicated in the drawings or specified: 2020 NEC, IBC 2021 National Fire Protection Association Standards (latest edition) Underwriters Laboratories, Inc. (UL) National Electrical Manufacturers Association (NEMA) Applicable local and state building codes ASHRAE Standards 90.1 VIRGINIA BUILDING CODE - RESIDENTIAL 2021. VIRGINIA BUILDING CODE - EXISTING BUILDING 2021. VIRGINIA BUILDING CODE - BUILDING 2021. VIRGINIA BUILDING CODE - ENERGY CONSERVATION 2021. B. Scope: This division covers all labor, equipment, supervision, appliances, materials, and operations necessary to complete the electrical work per these specifications, drawings, and contract documents. Work shall include labor, materials, permits, inspections, re-inspection fees, tools, equipment, transportation, insurance, temporary protection, lighting, supervision, and incidental items necessary for proper installation and operation. C. Substitutions/Approved Equal: Use only UL-labeled products where applicable. All materials must be new and in perfect condition. Any reference to specific brands or catalog numbers establishes a standard of quality; contractors may propose equal. D. Fees, Permits, and Regulations: Comply with all governing codes, ordinances, and regulations of city, county, and state authorities. Where local codes are not applicable, adhere to the latest NEC requirements. E. Contractor's Responsibilities: Coordinate work with other trades and utility companies. Ensure timely work schedules and material delivery. Employ qualified contractors and install materials and equipment in a neat condition. Maintain the integrity of fire-rated partitions, ensuring compliance with fire-stopping requirements as per IBC. Contractor is responsible for identifying all underground utilities before excavation, and coordinate with power utilities for service connections. The er s drawings shall be used as guide. Electrical contractor shall provide appropriate conductors per NEC requirements. If existing conditions are present, the contractor shall conduct a site visit to inspect the existing service and electrical conditions, ensuring they align with the electrical plans. Any discrepancies must be reported to the architect/owner before submitting a bid. F. Interpretation of Drawings: Drawings are diagrammatic and do not indicate exact conduit runs, outlet box locations, junction boxes, etc. Location on the drawings are approximate only. Report any discrepancies before proceeding with related work. If a conflict arises between the contract documents and any applicable code or standard, the most stringent requirement shall be applied to this project. Verify all figures and measurements prior to layout and shall be responsible for any errors that could have been avoided. Special attention must be given to code-required electrical clearances, and any discrepancies must be reported to the architect/owner immediately. G. Service and Metering: Coordinate with the utility company for service arrangements. H. Cutting and Patching: Coordinate all openings with the other trades. Unauthorized structural modifications must be approved by the architect/owner. I. Handling of Materials and Equipment: Protect materials from damage, moisture, dirt, and debris. Replace any damaged materials to the satisfaction of the architect/owner. Receive, store, handle, and deliver materials and equipment to the designated location. J. Cleanup: Maintain a clean worksite. Remove debris and leave premises in an orderly condition. Remove dirt, dust, paint, stains, and soil marks from all materials and equipment. K. Labels: Provide engraved rigid laminated phenolic labels for all equipment, disconnects, switches, electrical panels, etc. L. As-Built Drawings: Maintain accurate records of all changes from original plans and provide updated marked drawings upon project completion indicating all changes made. M. Guarantee and Service: The contractor shall guarantee equipment, materials, and workmanship. N. Submittals: Submit equipment confirmation and shop drawings per project schedule to the building department on the contract documents review process. O. Inspections: The Bldg. department inspector will inspect work for compliance with plans and specifications. P. Interruption of Existing Service: Provide advance notice before outages affecting critical circuits. Q. Final Inspection and Tests: Complete all work, testing of all systems, provide results and corrective actions before final inspection.	PART 1 - PRODUCTS A. CONDUIT: Unless otherwise specified, conduit shall be installed as follows: Plastic Conduit: Provided by one of the following manufacturers (or an approved equivalent): Carlton Plastic Products Corp., Cantex Plastic Products, Hatfield Wire and Cable Company. Conduits that are exposed and susceptible to mechanical damage shall be rigid, heavy-wall or galvanized steel. Conduits exposed outdoors or embedded in floor slabs shall be rigid, heavy-wall, galvanized, or sherardized steel, or Schedule 80 PVC. Conduits installed below grade and outside the building shall be Schedule 40 heavy-wall, high-impact polyvinyl chloride (PVC) electrical conduit. B. COUPLINGS AND CONNECTORS: Couplings and connectors shall be manufactured by one of the following (or an approv Appleton Electric Company, Raco, Steel City C. OUTLET BOXES: All 125v single phase equipment receptacles to be gfci protected on gfci breaker circuit Floor Box:: Hubbell #8-2536 with S-3182 brass carpet flange and S-3925 flap-type cover for duplex receptacles (or an approved equivalent). D. PANELBOARDS: Panelboards shall be from one of the following manufacturers (or an approve: Eaton, Square D, General Electric, or Siemens. All Panelboards must match project specifications. All panels shall be UL listed and match the project specifications. E. WIRE: Furnish and install conductors as specified in the drawings. All conductors shall be copper rated for 600 volts Wires larger than #10 to be stranded in accordance with ASTM. All wiring conductors shall be insulated electrical grade annealed copper or ROMEX. F. WIRING DEVICES: Smoke detectors: Shall be hard wired (110 volt) to a non-switchable kitchen or bathroom lighting circuit and shall not be connected on to the load side of a ground fault interrupter. Powered by house electric with battery backup and interconnected. Installed in each sleeping room and hall or area immediately outside each room and at the highest point of each story of residence. Carbon monoxide: Shall be provided within 10 feet of each room used for sleeping purposes per requirements described in the state statues 9B-3.0472 Receptacles: All 125v single phase equipment receptacles to be gfci protected on gfci breaker circuit 406.12 tamper-resistant receptacles in all areas specified in 210.52, all nonlocking-type 125-volt, 15- and 20-ampere receptacles shall be listed tamper-resistant receptacles. 210.8(a) dwelling units. all 125-volt, single-phase, 15- and 20- ampere receptacles installed in the locations specified in 210.8(a)(1) through (10) shall have ground-fault circuit interrupter protection for personnel. - bathrooms - garages, and also accessory buildings that have a floor located at or below grade level not intended as habitable rooms and limited to storage areas, work areas, and areas of similar use - outdoors. exception: receptacles that are not readily accessible and are supplied by a branch circuit dedicated to electric snow-melting, deicing, or pipeline and vessel heating equipment shall be permitted to be installed in accordance with 426.26 or 427.22, as applicable. - crawl spaces — at or below grade level - unfinished portions or areas of the basement not intended as habitable rooms. exception: a receptacle supplying only a permanently installed fire alarm or burglar alarm system shall not be required to have ground-fault circuit-interrupter protection. informational note: see 760.41(b) and 760.121(b) for power supply requirements for fire alarm systems. receptacles installed under the exception to 210.8(a)(5) shall not be considered as meeting the requirements of 210.52(g). - kitchens — where the receptacles are installed to serve the countertop surfaces - sinks — where receptacles are installed within 1.8 m (6 ft) from the top inside edge of the bowl of the sink - bathhouses - bathtubs or shower stalls — where receptacles are installed within 1.8 m (6 ft) of the outside edge of the bathtub or shower stall - laundry areas G. SURGE PROTECTION DEVICE (or an approved equiva: PQ Protection "PQ Series", Current Technology "TG Series", Innovative Technology "PTX Series", Square D Surgelogic "EMA Series", General Electric "Tranquell Series" PART 2 - EXECUTION A. GROUNDING: Grounding shall comply with NEC Article 250 and include: Proper ground conductor sizing for panel feeders and branch circuits. Equipment ground conductors shall be continuous from the service entrance and separate from the neutral conductor. The neutral shall not serve as the ground for equipment. B. RACEWAYS: Furnish and install underground raceways for power company service and telephone company service as per utility company specifications and coordinate the exact routing of these raceways with the utility company. All raceways in finished areas shall be concealed and all outlets in finished areas shall be mounted flush with finished walls. All raceways and non-current carrying metal enclosures shall be mechanically and electrically grounded. A minimum 24" radius elbows and conduits shall be used when rising from below the floor to the surface of walls, except for low-voltage raceways. Low-voltage raceways (for systems operating at 70 volts or below) shall be Type 4 polyvinyl chloride (PVC), UL-listed non-metallic. All low-voltage raceways must have bushings at all terminals. A nylon pull cord with a minimum 50-pound test rating shall be left in all raceways where conductors are not installed. C. OUTLET BOXES: Boxes shall be independently secured to the structure, separate from conduit supports. Plaster rings shall be installed for recessed units. The contractor shall coordinate unit locations shown on electrical drawings with actual locations established by the architect or mechanical contractor. Any discrepancies must be clarified before proceeding with installation.	D. PANELBOARDS: Each panelboard shall include a laminated, rigid plastic label below the directory with contractor details and year of installation. Breakers shall be clearly numbered. For designated spaces, provide the necessary hardware for future breaker installations. and type of outlets. E. DISCONNECT SWITCHES: Disconnect switches shall be NEMA-rated duty, in compliance with Fed. Spec. W-S-865C, rated 240V for 208V systems. Each motor shall have a non-fused disconnect switch or breaker within sight of the motor location. Sized to the next standard size. Exterior switch shall be NEMA 3R rated min. F. BRANCH CIRCUIT WIRING: Conductors shall be copper, with no wire smaller than #14 AWG used for any branch circuit. Conductor insulation shall be Type THHN (U.N.O) except for ballast connections. All joints shall be completed using only Scotch-Lock connectors of types Y, G, R, or B. At each outlet, an 8-inch wire loop shall be left for device connection. Fluorescent fixture wiring shall comply with the National Electrical Code, Article 410-24, and use THHN insulation. Outlets shall be wired as specified in the plans. must be considered where applicable. For 20A circuits exceeding 75 feet in length, a minimum of #10 AWG shall be before the first receptacle. G. WIRING DEVICES: Provide all wiring devices indicated on plans. Color of device selected by architect/owner at time of submittal. H. DEVICE PLATES: Wiring devices shall have plastic-type plates in colors selected by the architect/owner. I. FIXTURES: Fixtures shall be installed per the fixture schedule (or an approved equivalent), wired as designated in the drawings. manufacturers include Jefferson, Advance, Sola, or an approved equal energy-saving type. J. LAMPS: LED lighting shall be provided throughout. K. POWER AND CONTROL WIRING TO EQUIPMENT: Install all wiring from the panel to the motor terminal, provide all required disconnects and complete all power connections within these circuits. Control equipment, including motor starters, relays, line voltage controls, transformers, low voltage controls, and devices necessary for the operation of heating, air conditioning, ventilation, and plumbing systems, shall be supplied and installed by the respective subcontractor. L. MOTOR STARTER: Contractors shall supply all motor starters that are not provided with the equipment.																		
GENERAL NOTES Weatherproof devices shall include lift cover plates for exterior applications. A/C compressors shall be installed above the base flood elevation. Electrical outlets, receptacles and lighting below base flood elevation shall be installed at highest permitted elevation and shall be installed on a separate independent circuit from those in habitable areas. No appliance outlets shall be installed below the base flood elevations. Connect all emergency lighting (exit lights) to the same circuit as the normal lighting in the area, positionned ahead of any switches, or ensure compliance with NEC 700-12. Main circuit breaker panel shall be installed above the base flood elevation. All work shall be rigidly mounted and supported. Provide tamper-resistant receptacles per NEC 406.12. ARC-fault circuit- interrupter protection for the dwelling units per nec 210.12(a) 210.12(a)(1) a listed combination-type arc-fault circuit interrupter, installed to provide protection of the entire branch circuit. 210.12(a)(2) a listed branch/feeder-type afci installed at the origin of the branch-circuit in combination with a listed outlet branch-circuit type arc-fault circuit interrupter installed at the first outlet box on the branch circuit. the first outlet box in the branch circuit shall be marked to indicate that it is the first outlet of the circuit. 210.12(a)(3) a listed supplemental arc protection circuit breaker installed at the origin of the branch circuit in combination with a listed outlet branch-circuit type arc-fault circuit interrupter installed at the first outlet box on the branch circuit where all of the following conditions are met: (see nec) in combination with a listed branch-circuit overcurrent protective device where all of the following conditions are met: (see nec) equipment to obtain correct wire sizes and over-current protection prior to installation of rough electrical wiring. the electrical contractor shall make the electrical connection to all equipment requiring current. Existing raceways and cabling may be reused if compliant with NEC. Verify exact location of electrical outlets and lights prior to execution of rough-in work. overhead electrical conductor clearances, horizontal and vertical shall be maintained. All electrical devices and fixtures in all living quarters to be protected with AFI breaker. 515.21 - 515.37, the Residential Swimming Pool Safety Act. Electrical contractor to provide clearances for electrical equipment per NEC 110.26																				
PROJECT NAME & ADDRESS: NOVA PARKS 46442 PARK CHALET PL, STERLING, VIRGINIA, 20165 MARC O'GRADY DESIGN																				
<table><tr><th>No.</th><th>Description</th><th>Date</th></tr><tr><td>▲</td><td></td><td></td></tr><tr><td>▲</td><td></td><td></td></tr><tr><td>▲</td><td></td><td></td></tr><tr><td>▲</td><td></td><td></td></tr><tr><td>▲</td><td></td><td></td></tr></table>			No.	Description	Date	▲			▲			▲			▲			▲		
No.	Description	Date																		
▲																				
▲																				
▲																				
▲																				
▲																				
DRAWN BY: PLC REVISED BY: JPP PROJECT NO: 26 173 78 SHEET TITLE: ELECTRICAL DETAILS SHEET NUMBER: ED-101																				

HVAC NOTES - INTERNATIONAL BUILDING CODE

THIS DESIGN COMPLIES WITH INTERNATIONAL BUILDING, RESIDENTIAL, EXISTING RESIDENTIAL, MECHANICAL, AND ENERGY CODES. RESIDENTIAL BASIS OF DESIGN / CONTRACTOR NOTES:

These HVAC drawings, heat load calculations, and energy calculations are based on the architectural drawings provided for permit application.

Using the architectural construction drawings, ACCA HVAC design procedures were performed: (1) room by room heat load calculations are performed to determine the buildings thermal zones and room by room demands in accordance with manual J heat load calculation procedure (2) the heat load calculations were used to select the HVAC equipment capacities in compliance with manual S equipment selection procedure (3) the room by room demand calculations were used to design the duct system in accordance with manual D duct design (4) room air device type, size, and location were based on the rooms required cfm demand, the duct type, and room geometry, in accordance with manual T room air distribution selection procedure (5) Florida energy calculations were performed based on the ACCA hvac design procedures.

For detailed building envelope information (component layers, insulation R values, NFRC glass values, component types and colors, quantity, etc.) see the "Energy Code Calculations." HVAC installer must field inspect the building envelope component types and sizes prior to any HVAC installation - be sure the building constructed matches the "Total Building Summary Loads" page, the room by room floor plan layout, and the energy code forms. Building envelope construction practice "average" was used in the building infiltration calculations, field verify the building envelope (air barrier in contact with the thermal barrier) fully encapsulates the conditioned space. HVAC installer must field verify sealed draft stops exist that are isolating the wall cavities from the exterior and/or hot vented attic spaces. Buildings with hot vented attic spaces require the air and thermal barriers to be located at the ceiling plane. Buildings with unvented attics / or single assembly roofs (solid flat, low slope, sealed pitched, open web flat truss) require the air and thermal layer be located at the roof plane. Note: acoustical tile ceilings are not air barriers, paper faced insulation is not an air barrier - thermal layers in contact with a grid ceiling are ignored in the heat load and energy code calculations.

The room air devices, air cfm values, and branch duct sizes shown per room are based on the peak cooling season design conditions with hvac equipment capacities based on manual S equipment selection procedure for the buildings specific site location. This peak demand makes up approximately 15% of the cooling season, the remaining 85% of the cooling season (part load conditions) requires dedicated dehumidification equipment if year round control of indoor moisture content is expected. Year round moisture control is not part of this construction drawing and requires the latent heat load calculations are performed at part load design conditions, resulting in latent demands at least 20% higher when compared to the peak design conditions. Dedicated dehumidification equipment is required to control moisture content year round in Florida. Dehumidification equipment (Honeywell DH-90 or Ultra-Air XT150H or similar) will monitor and control moisture content year round using a humidistat or dew point sensor. Provide ducted dedicated dehumidifier(s) for buildings that contain an unvented "sealed attic" space (example: spray foam insulation at roof deck underside or roof is insulated above the roof deck). Mount the dehumidifier(s) in the sealed attic near the roof peak. For buildings with a hot vented attic space, the dehumidification equipment is ducted to the conditioned space and controls the moisture content inside the conditioned space using a humidistat or dew point sensor. For healthier and cleaner indoor air, install a Plasma Air Model 600 ionizer or similar +/-or (optional) a large capacity HEPA filter.

These HVAC drawings were based on the architectural drawings provided for permit application. Any modifications to the building room layout, occupancy amount, building use or classification, building compass orientation, or building envelope component material type and / or size must be communicated to the original HVAC designer. HVAC Installer should red line sketch on these HVAC drawings any field changes to be made during construction and submit the "as built" red line sketch to the original HVAC designer for review and redesign - prior to any further HVAC installation. Alternate air ducts sizes must be equal to the listed size shown, don't exceed a 3/1 aspect ratio on alternate duct sizes. Don't install a cooling system into a building that is missing a full building envelope.

CODE OFFICIAL + HVAC CONTRACTOR NOTES:

International Building Code section abbreviations: IBC = Building, IMC = Mechanical, IEC = Energy

These HVAC drawings are not intended to show exact detail of every item required to meet the code requirements. The proposed duct routing is general in nature, field conditions and building structure may dictate the exact mounting configuration of the HVAC system(s). International building code sections are listed for each HVAC drawing symbol to be used by the installing HVAC contractor and code official(s). Installer should reference the code sections prior to fabrication or installation of any HVAC system component. These HVAC drawings comply with the International Building Codes sections IBC101.4.2, IBC101.4.6, IBC105.3.1.2, IBC107.3.5 "Mechanical" Plan review criteria.

- HVAC installation must comply with the International building codes, energy conservation codes, and mechanical codes. Obtain all required permits and inspections per code sections IBC105, IBC107, and IBC110.
- Ventilation air required per IBC1203 + IMC401.2 + IEC403.6. This design could includes mechanically induced controlled ventilation for buildings that contain a forced air duct system, pressurizing the building interior during air handler operation, provided by a ventilation air duct and mechanical damper. In cases when the ventilation rate is satisfied by the building infiltration rate, no ventilation air duct will be shown. The ventilation rate may also be satisfied by use of properly sized windows to the outdoors per IBC1203.5, manually operated by the occupant. For large buildings with few occupants, the building envelope infiltration rate may satisfy the minimum ventilation rate required, see "Total Building Summary Loads" page for infiltration rate. Small buildings with many occupants will usually require a ventilation air duct, motorized damper, and ventilation air duct routed to an approved exterior location, see "Total Building Summary Loads" page for ventilation air cfm amount. A mandatory blower door test, IEC402.4.1.2, must be performed to quantify the building's natural infiltration air cfm rate and determine the design ventilation air cfm amount will successfully pressurize the building's interior. If motorized ventilation is used the air damper will be dual controlled by both "run-time" and "manually on" control cycles. Installer may also add an air handler fan cycle to provide automatic air exchange during part load conditions. Interlock the ventilation air damper motor with the air handler fan motor for "run time" cycling. The occupants may also select "fan-on" cycle for continuous ventilation when the outdoor conditions are favorable (low heat and low moisture content).
- Coordinate location of all equipment, fans, air devices, and building penetrations with the general contractor. Coordinate air device locations with the electrical contractor (smoke detectors), G.C., and building owner - the proposed hvac air device locations are shown in the ideal location per Manual T room air device selection procedure, design alternate air device locations per Manual T. HVAC installer must field verify clearances and accessibility prior to fabrication or installation of the HVAC components. Protect the building structure per IMC302. Provide accessibility for elevated equipment per IMC306.5. Fabricate and install HVAC system components per IMC304 + IBC1307, and product manufacturers envelope penetration detail. IBC107.3.5 wind data for wall and roof penetrations, HVAC product installation instructions, HVAC equipment manufacturers installation instructions, and AHRI energy + equipment manufacturers expanded capacity ratings must be available on the construction site at time of code official inspections per IBC110.
- All exterior building penetrations and exterior mounted HVAC equipment, wall vent caps, roof vent caps, intake air vents, and relief air caps, etc. must comply with IBC1609 wind loads. HVAC installing contractor must supply engineered product or equipment ANSI/AMCA 540 test information for attachment to the building envelope component per section IBC1609.1.2. A structural engineer's sealed drawing detail may be required for exterior equipment mounted above ground level per IBC1510.10. This hvac design does not provide structural, equipment, or hood tie down details. See structural engineer's drawings and details for equipment support and tie down info when equipment manufacturers engineered data is not available.
- All duct sizes shown are clear interior "free area" duct dimensions based on IMC603.2 manual D duct design. Add 3" to listed sizes for R-6 exterior duct dimensions - add 4" to listed sizes for R-8 exterior duct dimensions. Fiberglass duct board shown is equal to Knauf 1.5 or similar", R-6, fabricate and install per SMACNA standards. Flexible ducts shown are equal to Atco 36 series R-6 class one air duct or similar, not limited in length per IMC603.6.1.1. Construct all ducts per manufacturer's installation instructions and SMACNA standards for S: maximum 1" w.g. S: suspend and support the ducts from the building structure per IMC603. Use 26 gauge sheet metal or rigid foil face fiberglass duct board for rigid duct penetrations of private garages per IMC603.7 and protect ducts per IMC607. Mastic seal all ducts installed outside the building's thermal envelope per UL-181 and IMC603.9. Provide accessible volume control dampers in branch ducts per IMC603.18. General exhaust ducts used for exhaust fan duct, clothes dryer duct, make up air duct, and residential cooking appliance duct up to 14" in diameter (or equal free area in rectangular) are constructed from 28 gauge sheet metal "snap lock pipe or similar", use SMACNA standards for required gauge of larger metal ducts, mastic seal ducts per table FMC603.9. Use flexible air ducts or 28 gauge sheet metal "snap lock pipe or similar" for ventilation air ducts.
- Provide a condensate drain piping system per IMC307, and a refrigerant piping system per IMC1107. Extend condensate drain discharge 12" minimum from the building exterior wall, discharge to grass or other approved location, a condensate drywell may be required. Provide piping and supports for both condensate and refrigerant piping per FMC305.
- Provide a balanced return air system per IMC601.6. All enclosable rooms require a 1" undercut on the interior door, allowing about 30 cfm of air relief per 30" wide door. Habitable spaces require door undercut plus a means for air transfer or a ducted return air. Pressure differentials across the restricted room can't exceed .01 inch w.g. Enclosable rooms located on the building exterior envelope should be balanced slightly positive. Size ducted transfer air ducts free area 1.5 times larger than the supply air delivered to the enclosed room(s). Size direct through wall or door grilles at 50 square inches of grille free area to 100 cfm.
- Attic mounted equipment must contain a shut off device to alert the home owner if the primary condensate drain line is not working properly. Using 16 point bold text, Post a "home owner notice" on the electrical service panel alerting the home owner that the HVAC air handler is located in the attic space, see IEC403.3.6 for full compliance description and "notice to home owner" language required. Provide a sealed attic access panel for hot vented attics, a safe workers access deck, an attic light fixture with switch, and an electrical plug outlet.
- Upon completion of the HVAC system installation, per manual D chapter 16, test equipment operating capacities for both cooling and heating to verify the equipment is functioning to the listed capacity. Verify the air handler total air flow cfm matches the HVAC equipment schedule or heat load calculation minimum system airflow rate. No duct system is self-balancing, adjust each room's branch duct volume damper to achieve the listed air flow values shown or to meet the building owner's needs. Use the air device volume damper for the last 10% of air balance to avoid noise at the air device face. Room air flow balance for buildings with concealed ducts can be accomplished during the "rough in" stage of construction, prior to concealment of ducts. With the building air barrier fully intact, install and operate the air handler until proper air flow is adjusted per room, a balanced return air path must also be present. Use a self-compensating air flow hood for airflow measurements, perform air balance procedure in accordance with manual B or NEBB standards. When required by code, provide the air balance report to the building owner and code officials. A blower door test must be performed to verify that the building envelope natural leakage rate does not exceed the infiltration or ventilation cfm rate shown on the "Total Building Summary Loads" page.
- Contractor to locate all programmable thermostats per 308.1 general fbc-a - thermostat reach ranges shall comply w/ table 308 (48" a.f.f.)
- HVAC sequence of proper operation: The thermostat is set to "auto" mode and will monitor the conditioned space temperature and provide heating, cooling, and ventilation when required. Upon a call for heating, the air handler fan interlock will open the ventilation air damper and operate the indoor fan and heat pump condenser and/or electric heat strip until the space conditions are satisfied - use a 70 degree thermostat setting during the heating season. Upon a call for cooling, the air handler fan interlock will open the ventilation air damper and operate the indoor fan and heat pump condenser until the space conditions are satisfied - use a 75 degree thermostat setting during the cooling season. During favorable outdoor conditions, when the temperature and humidity is low - the thermostat may be set to "fan on" for continuous air circulation and introduction of ventilation air. For newly constructed homes to be energy code compliant (IEC403.1), the HVAC installer must set the programmable thermostat to provide heating up to 70 degrees and cooling down to 78 degrees. Be sure not to overcool the conditioned space - overcooling a building is defined as a temperature lower than the dew point temperature for the interior conditioned space - most buildings can easily be driven to dew point temperatures during part load conditions. Overcooling a building successfully requires specialized HVAC equipment and controls. The heat removal (sensible heat) and moisture removal (latent heat) must be de-coupled and independently controlled for buildings to achieve temperature's lower than the "dew point safe" energy code set point of 78 degrees.

Transfer Grille Sizing Calculations

Table 1 shows the sizing specifications for using 10", 12" or 14" wide transfer grilles with 70% free area as a function of room supply air flow. The transfer grille sizing includes allowance for one 32" by 1/2" door undercut.

Table 1

Total Room Supply Airflow (CFM)	Transfer grille height required for listed width (in inches)			Jump Duct Dia. Required (in)	High/Low Wall Transfer Stud Spacing Needed (in)
	10"	12"	14"		
75 or less	4	4	4	6	16
76 - 100	6	6	4	8	16
101 - 125	8	6	6	8	24
126 - 150	10	8	8	10	n/a
151 - 175	12	10	8	10	n/a
176 - 200	14	12	10	12	n/a
201 - 225	16	14	12	12	n/a
226 - 250	18	14	12	12	n/a
251 - 275	20	16	14	14	n/a
276 - 300	22	18	16	14	n/a
301 - 325	24	20	16	14	n/a
326 - 350	26	22	18	18	n/a

Based on Q = 1.07 A dP^{0.5} for square edged orifice flow
where: Q = room supply flow (cfm)
1.07 = constant, including unit conversions
A = free area (in2)
dP = pressure difference between room and common area (Pa)
Adjust free area up to account for more friction pressure loss. For example:
0.6 for high/low wall transfer
0.7 for through-wall transfer and jump duct

KEYNOTES

- PROVIDE NEW AIR HANDLER PER SCHEDULE, MOUNT FROM STRUCTURE IN CEILING CAVITY. ACCESS THROUGH HATCH. SEE ARCHITECTURAL DRAWINGS FOR FULL ACCESS DETAILS.
- PROVIDE NEW AIR HANDLER PER SCHEDULE, MOUNT TO FLOOR.
- PROVIDE CONDENSING UNIT(S) PER SCHEDULE. MOUNT TO SLAB PER DETAIL.
- ROUTE REFRIGERANT PIPING UP IN WALL FURRING TO CEILING CAVITY. ROUTE TO CORRESPONDING AIR HANDLER AS INDICATED.
- ROUTE REFRIGERANT PIPING UP IN WALL FURRING TO 2ND FLOOR.
- PROVIDE BROAN PRESSURE SENSOR FOR MAKE-UP AIR DAMPER. SENSOR TO PROVIDE SIGNAL TO OPEN MAKE-UP AIR DAMPER WHEN HOOD FAN IS ENERGIZED.
- PROVIDE HOOD EXHAUST DUCT TO GRILL HOOD. SEE ARCHITECTURAL PLANS FOR HOOD INFORMATION.
- PROVIDE NEW DEHUMIDIFIER PER SCHEDULE, MOUNT TO FLOOR IN MECHANICAL ROOM.
- PROVIDE NEW DEHUMIDIFIER PER SCHEDULE, MOUNT FROM STRUCTURE IN CEILING CAVITY. ACCESS THROUGH HATCH.
- PROVIDE WALL CAP SIZED TO MATCH CONNECTED EXHAUST DUCTWORK PER REQUIREMENTS OF THE FBC-M.
- PROVIDE STAINLESS STEEL GRILLE PER SCHEDULE. MOUNT GRILLE IN BOTTOM OF SOFFIT.
- PROVIDE 4" OR 6" X-VENT SIZED TO MATCH CONNECTED EXHAUST DUCT.
- PROVIDE BROAN MODEL #MD10TU AUTOMATIC MAKE-UP AIR DAMPER, NORMALLY CLOSED, INTERLOCKED TO OPEN WHEN KITCHEN EXHAUST HOOD FAN IS IN OPERATION. PROVIDE 12" DUCT UP TO WALL CAP.
- PROVIDE 4" DRYER EXHAUST VENT UP TO ROOF CAP.

SOME KEYNOTES MAY NOT BE USED ON THIS PLAN

NOTES:

- ALL DUCT INSIDE DIMENSIONS AS NOTED


TAG	DESCRIPTION	NOTES
SD	SUPPLY DIFFUSER	1
RG	RETURN GRILLE	1
TG	TRANSFER GRILLE	2
EF	EXHAUST FAN	3
AHU	INTERIOR UNIT	4
CU	EXTERIOR UNIT	4
D	DRYER	5

SYMBOL LEGEND

"ALL LISTED SUPPLY AIRFLOWS (CFM) ARE CALCULATED FOR HEATING-MODE OPERATION UNLESS OTHERWISE NOTED. COOLING-MODE AIRFLOW REQUIREMENTS MAY DIFFER. CONTRACTOR SHALL REFER TO THE COOLING/HEATING AIRFLOW TABLE FOR SEASONAL AIRFLOW VALUES AND SHALL ADJUST BALANCING DAMPERS ACCORDINGLY TO ACHIEVE PROPER SYSTEM PERFORMANCE IN BOTH COOLING AND HEATING MODES."

NOTES:

- SEE AIR DISTRIBUTION SCHEDULE
- SEE TRANSFER GRILL TABLE (OPTIONAL)
- SEE EXHAUST FAN DETAILS ON SHEET MD-100 (OCCUPANCY LIGHT SWITCH OPERATED UNLESS NOTED OTHERWISE)
- SEE AHU, CU DETAILS ON SHEET MD-100
- SEE HOOD EXHAUST DETAILS ON SHEET MD-100
- ALL DIFFUSERS AND GRILLES ARE IN THE FLOOR.
- ALL DUCTWORK WILL RUN UNDER THE FLOOR STRUCTURE WITHIN THE CRAWL SPACE.

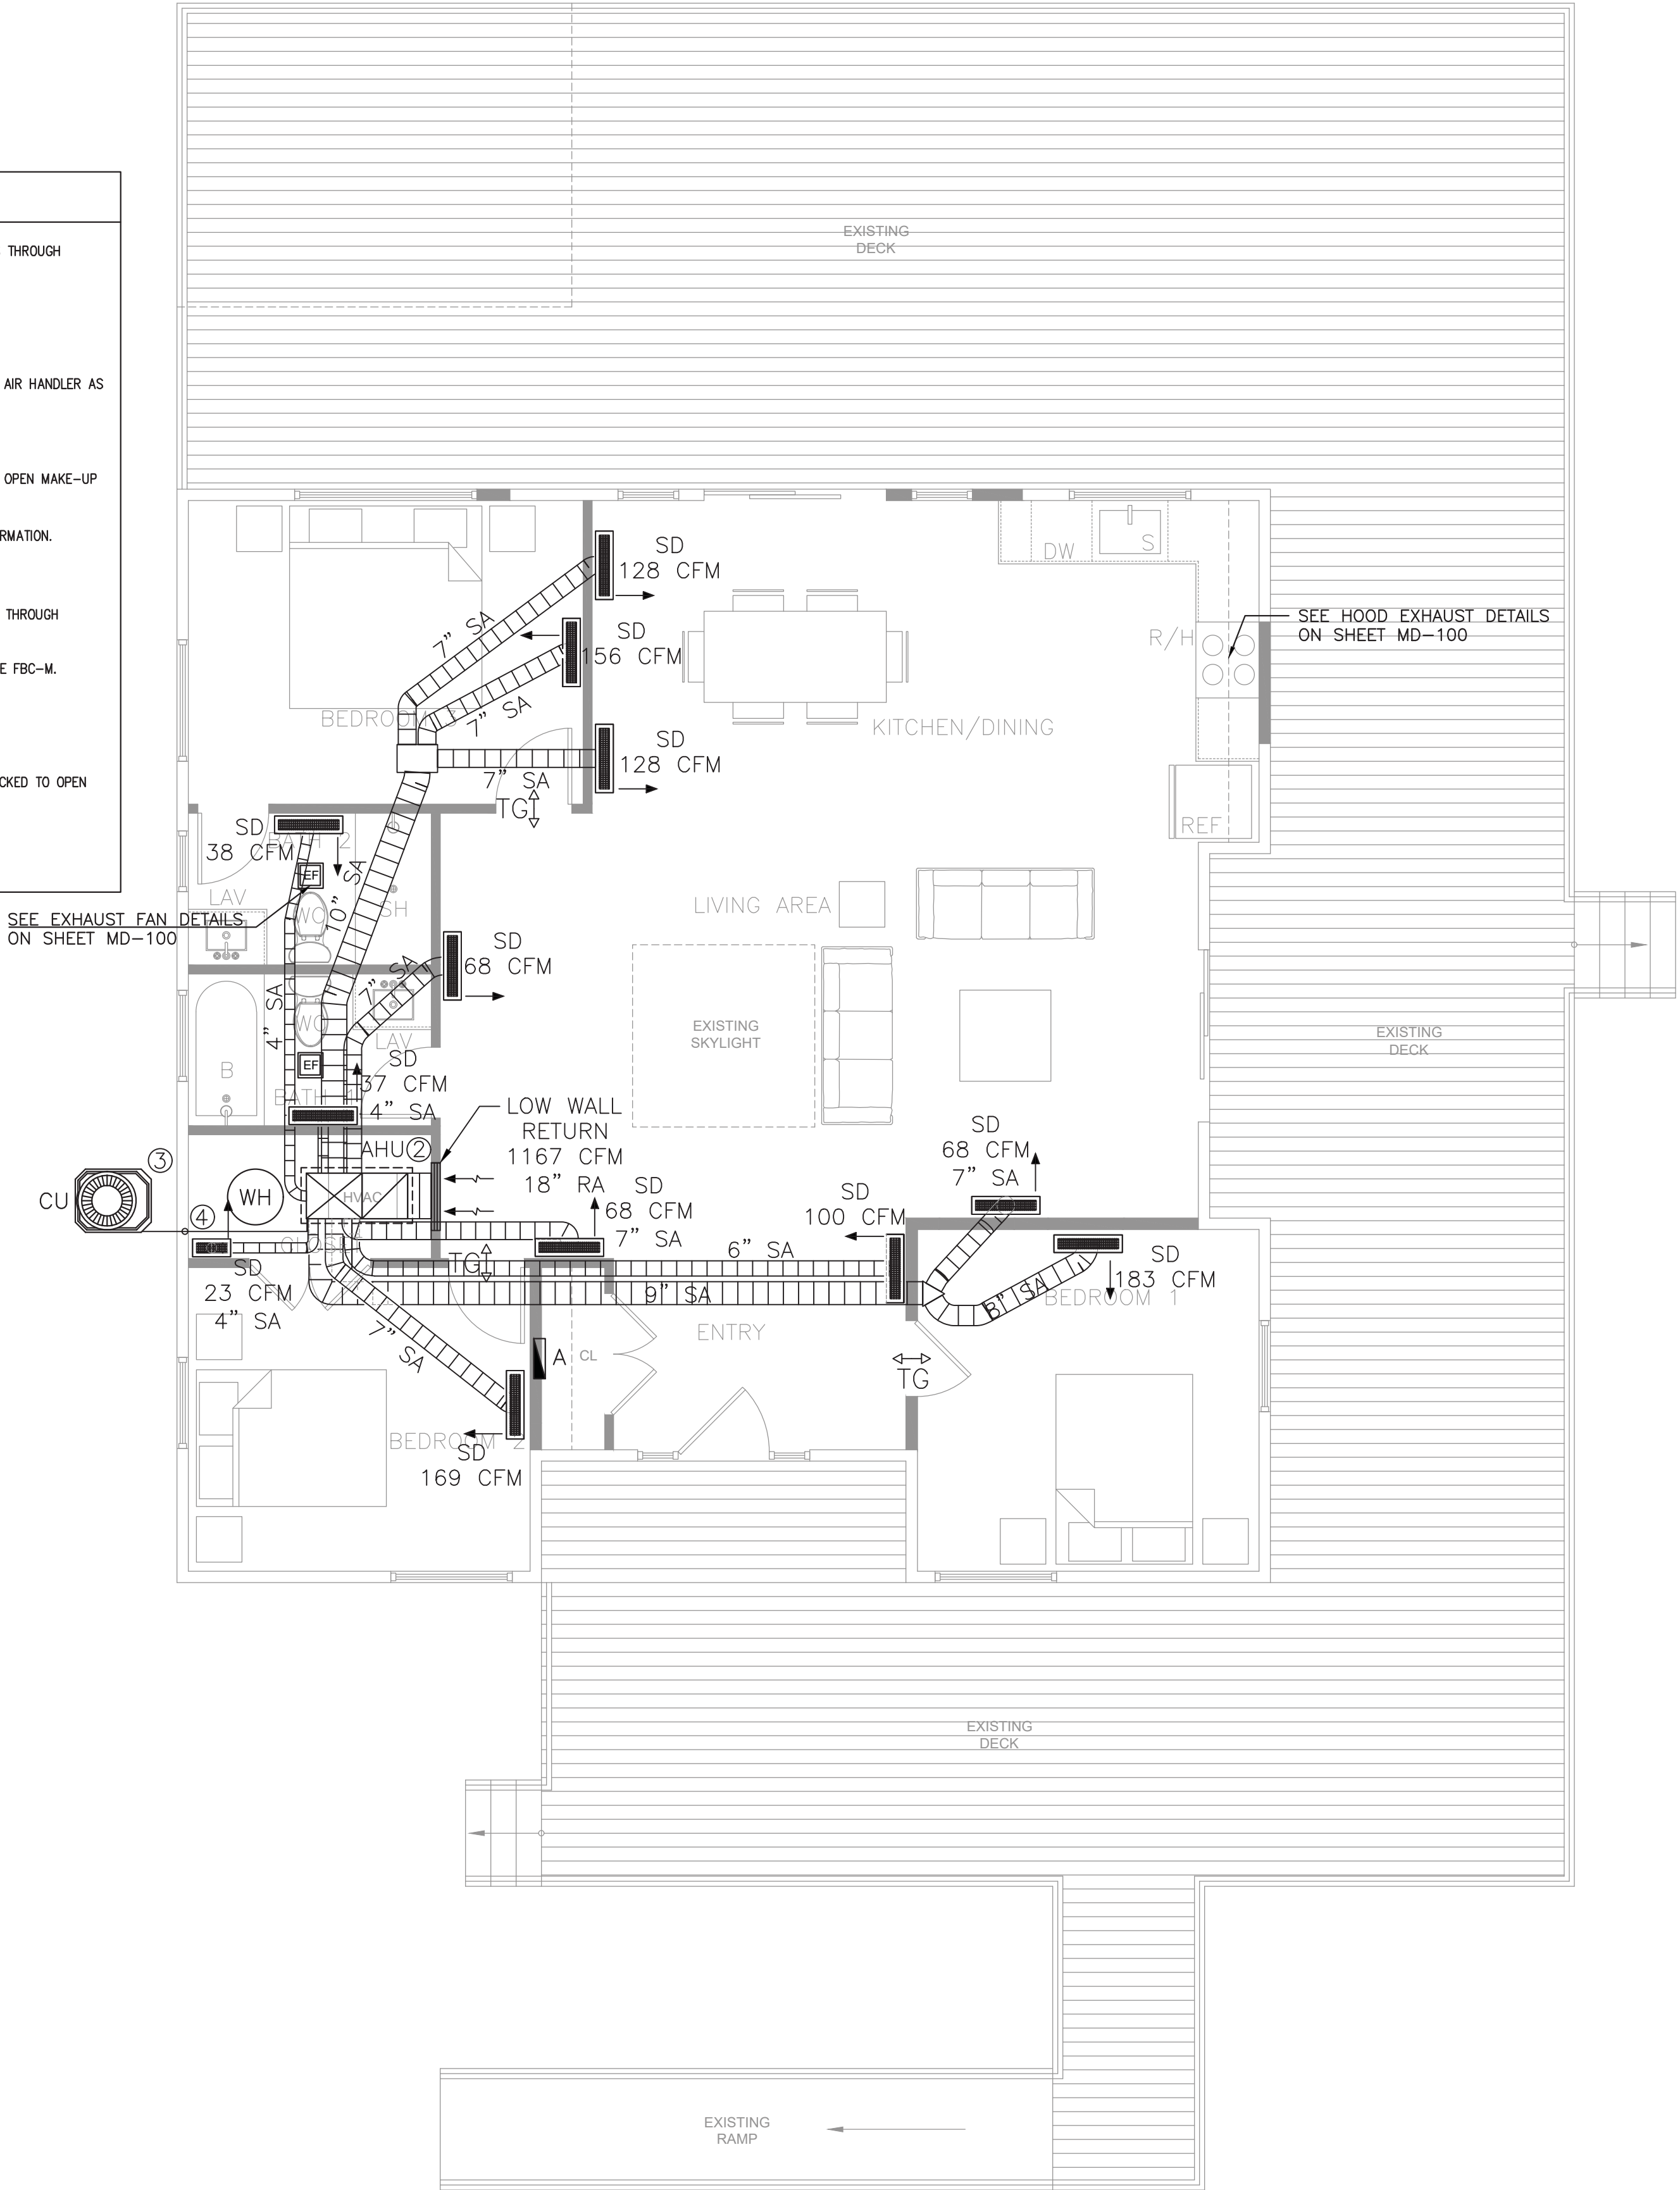

ALL THE DESIGN AND DETAILS ON THIS PLAN ARE THE PROPERTY OF LIGHTNING ENGINEERING. THIS DOCUMENT IS NOT TO BE USED, COPIED OR REPRODUCED WITHOUT THE WRITTEN PERMISSION OF LIGHTNING ENGINEERING.

I HEREBY CERTIFY AS THE BUILDING DESIGN ENGINEER OF RECORD, THAT THE DESIGN AND DETAILS SHOWN ON THESE DRAWINGS ARE THE PROPERTY OF LIGHTNING ENGINEERING. THIS DOCUMENT IS NOT TO BE USED, COPIED OR REPRODUCED WITHOUT THE WRITTEN PERMISSION OF LIGHTNING ENGINEERING. WITH THE BUILDING CODE WITH SUPPLEMENTS.

LIGHTNING ENGINEERING
4161 TAMAMI TRAIL UNIT 101
PORT CHARLOTTE, FL 33980
TEL 813-979-8195
FAX 813-979-8195

NOVA PARKS
46442 PARK CHALET PL, STERLING, VIRGINIA, 20165
MARC O'GRADY DESIGN

PROJECT NAME & ADDRESS:

No.	Description	Date
▲		
▲		
▲		
▲		

DRAWN BY: PLC

REVISED BY: JPP

PROJECT NO: 26 173 78

SHEET TITLE:

MECHANICAL PLAN

SHEET NUMBER:

M-100

MECHANICAL PLAN

1/4" = 1'-0"

AHU

Design Information					
	Htg	Cig	Infiltration		
Outside db (°F)	18	92	Method	Simplified	
Inside db (°F)	70	75	Construction quality	Semi-tight	
Design TD (°F)	52	17	Fireplaces	0	
Daily range	-	M			
Inside humidity (%)	50	50			
Moisture difference (gr/lb)	44	40			

HEATING EQUIPMENT			COOLING EQUIPMENT		
Make	CARRIER		Make	CARRIER	
Trade	CARRIER		Trade	CARRIER	
Model	27SCA536A00300		Cond	27SCA536A00300	
Model	214101253		Coil	FJ5ANXB36L00	
AHRI ref			AHRI ref	214101253	


Efficiency	7.5 HSPF2	Efficiency	12.0 EER2,14.5 SEER2
Heating input		Sensible cooling	24500 Btuh
Heating output	35600 Btuh @ 47°F	Latent cooling	10500 Btuh
Temperature rise	28 °F	Total cooling	35000 Btuh
Actual air flow	1167 cfm	Actual air flow	1167 cfm
Air flow factor	0.051 cfm/Btuh	Air flow factor	0.049 cfm/Btuh
Static pressure	0.50 in H2O	Static pressure	0.50 in H2O
Space thermostat		Load sensible heat ratio	0.92

Backup:
Input = 7 kW, Output = 22309 Btuh, 100 AFUE

ROOM NAME	Area (R²)	Htg load (Btuh)	Cig load (Btuh)	Htg AVF (cfm)	Cig AVF (cfm)
BEDROOM 2	132	3282	2155	169	105
BEDROOM 1	144	3554	1987	183	97
CLOSET	34	439	166	23	8
BATH 1	47	717	688	37	33
BATH 2	47	739	780	38	38
BEDROOM 3	135	3035	3005	156	146
ENTRY	84	1953	906	100	44
KITCHEN/DINING	248	4995	3913	257	190
LIVING AREA	354	3972	10374	204	505
AHU	1224	22686	23975	1167	1167
Other equip loads		0	0		
Equip. @ 0.97 RSM			23304		
Latent cooling			2120		
TOTALS	1224	22686	25424	1167	1167


Heating

Component	Btuh/R²	Btuh	% of load
Walls	4.5	4341	19.1
Glazing	18.1	5611	24.7
Doors	0	0	0
Ceilings	1.1	1271	5.6
Floors	2.0	2435	10.7
Infiltration	2.3	2842	12.5
Ducts		6165	27.3
Piping		0	0
Humidification		0	0
Ventilation		0	0
Adjustments		0	0
Total		22686	100.0

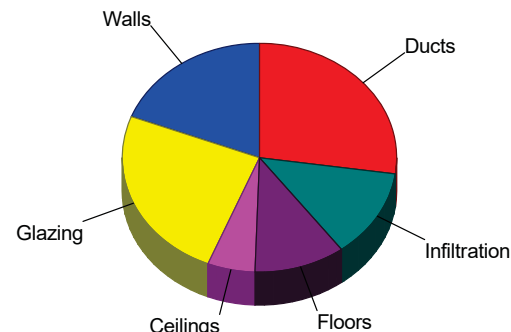

Cooling

Component	Btuh/R²	Btuh	% of load
Walls	1.8	1785	7.4
Glazing	34.6	10693	44.6
Doors	0	0	0
Ceilings	1.1	1271	5.3
Floors	0.7	808	3.4
Infiltration	0.4	487	2.0
Ducts		6110	25.5
Ventilation		0	0
Internal gains		2820	11.8
Blower		0	0
Adjustments		0	0
Total		23975	100.0

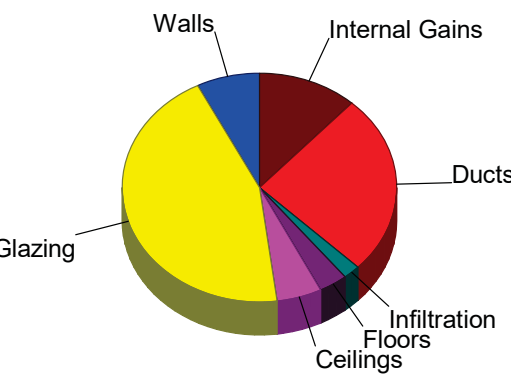

Latent Cooling Load = 2120 Btuh
Overall U-value = 0.075 Btuh/ft²-°F, Window / Floor Area = 25.3 %

WARNING: window to floor area ratio = 25.3% - more than 25%.

LBP/LBPH/LBM/LBMH

Linear Bar Grille

PERFORMANCE DATA

Heavy Duty Mandrel Linear Bar Grille (LBMH) – Core 15A

Size	Static Pressure (in. w.g.)	0.011	0.024	0.044	0.069	0.098	0.133	0.175	0.224	0.275
1 1/2 in.	Throw	1.1	2.2	4.4	6.6	8.8	11.1	13.3	15.5	17.7
	Side or Floor	1.1	2.2	4.4	6.6	8.8	11.1	13.3	15.5	17.7
	Side Wall	2.4	4.8	9.6	14.4	18.8	23.2	27.6	32.0	36.4
2 in.	Throw	1.1	2.2	4.4	6.6	8.8	11.1	13.3	15.5	17.7
	Side or Floor	1.1	2.2	4.4	6.6	8.8	11.1	13.3	15.5	17.7
	Side Wall	3.5	7.0	14.0	21.0	27.5	35.0	42.5	50.0	57.5
2 1/2 in.	Throw	1.1	2.2	4.4	6.6	8.8	11.1	13.3	15.5	17.7
	Side or Floor	1.1	2.2	4.4	6.6	8.8	11.1	13.3	15.5	17.7
	Side Wall	4.6	9.2	18.4	27.6	36.8	46.0	55.2	64.4	73.6
3 in.	Throw	1.1	2.2	4.4	6.6	8.8	11.1	13.3	15.5	17.7
	Side or Floor	1.1	2.2	4.4	6.6	8.8	11.1	13.3	15.5	17.7
	Side Wall	5.7	11.4	22.8	34.2	45.6	57.0	68.4	79.8	91.2
3 1/2 in.	Throw	1.1	2.2	4.4	6.6	8.8	11.1	13.3	15.5	17.7
	Side or Floor	1.1	2.2	4.4	6.6	8.8	11.1	13.3	15.5	17.7
	Side Wall	6.8	13.6	27.2	40.8	54.4	68.0	81.6	95.2	108.8
4 in.	Throw	1.1	2.2	4.4	6.6	8.8	11.1	13.3	15.5	17.7
	Side or Floor	1.1	2.2	4.4	6.6	8.8	11.1	13.3	15.5	17.7
	Side Wall	7.9	15.8	31.6	47.4	63.2	79.0	94.8	110.6	126.4
5 in.	Throw	1.1	2.2	4.4	6.6	8.8	11.1	13.3	15.5	17.7
	Side or Floor	1.1	2.2	4.4	6.6	8.8	11.1	13.3	15.5	17.7
	Side Wall	9.0	18.0	36.0	54.0	72.0	90.0	108.0	126.0	144.0
6 in.	Throw	1.1	2.2	4.4	6.6	8.8	11.1	13.3	15.5	17.7
	Side or Floor	1.1	2.2	4.4	6.6	8.8	11.1	13.3	15.5	17.7
	Side Wall	10.1	20.2	40.4	60.6	80.8	101.0	121.2	141.4	161.6

Heavy Duty Mandrel Linear Bar Grille (LBMH) – Core 16A

Size	Static Pressure (in. w.g.)	0.013	0.027	0.048	0.070	0.111	0.155	0.199	0.253	0.31
1 1/2 in.	Throw	1.1	2.2	4.4	6.6	8.8	11.1	13.3	15.5	17.7
	Side or Floor	1.1	2.2	4.4	6.6	8.8	11.1	13.3	15.5	17.7
	Side Wall	2.6	5.2	10.4	15.6	20.8	26.0	31.2	36.4	41.6
2 in.	Throw	1.1	2.2	4.4	6.6	8.8	11.1	13.3	15.5	17.7
	Side or Floor	1.1	2.2	4.4	6.6	8.8	11.1	13.3	15.5	17.7
	Side Wall	3.7	7.4	14.8	22.2	29.6	37.0	44.4	51.8	59.2
2 1/2 in.	Throw	1.1	2.2	4.4	6.6	8.8	11.1	13.3	15.5	17.7
	Side or Floor	1.1	2.2	4.4	6.6	8.8	11.1	13.3	15.5	17.7
	Side Wall	4.8	9.6	19.2	28.8	38.4	48.0	57.6	67.2	76.8
3 in.	Throw	1.1	2.2	4.4	6.6	8.8	11.1	13.3	15.5	17.7
	Side or Floor	1.1	2.2	4.4	6.6	8.8	11.1	13.3	15.5	17.7
	Side Wall	5.9	11.8	23.6	35.4	47.2	59.0	70.8	82.6	94.4
3 1/2 in.	Throw	1.1	2.2	4.4	6.6	8.8	11.1	13.3	15.5	17.7
	Side or Floor	1.1	2.2	4.4	6.6	8.8	11.1	13.3	15.5	17.7
	Side Wall	7.0	14.0	28.0	42.0	56.0	70.0	84.0	98.0	112.0
4 in.	Throw	1.1	2.2	4.4	6.6	8.8	11.1	13.3	15.5	17.7
	Side or Floor	1.1	2.2	4.4	6.6	8.8	11.1	13.3	15.5	17.7
	Side Wall	8.1	16.2	32.4	48.6	64.8	81.0	97.2	113.4	129.6
5 in.	Throw	1.1	2.2	4.4	6.6	8.8	11.1	13.3	15.5	17.7
	Side or Floor	1.1	2.2	4.4	6.6	8.8	11.1	13.3	15.5	17.7
	Side Wall	9.2	18.4	36.8	55.2	73.6	92.0	110.4	128.8	147.2
6 in.	Throw	1.1	2.2	4.4	6.6	8.8	11.1	13.3	15.5	17.7
	Side or Floor	1.1	2.2	4.4	6.6	8.8	11.1	13.3	15.5	17.7
	Side Wall	10.3	20.6	41.2	61.8	82.4	103.0	123.6	144.2	164.8

LBP/LBPH/LBM/LBMH

Linear Bar Grille











PERFORMANCE DATA

Heavy Duty Mandrel Linear Bar Grille (LBMH) Core 25B/25C

Size	Static Pressure (in. w.g.)	0.01	0.024	0.04	0.064	0.088	0.121	0.161	0.204	0.25
1 1/2 in.	Throw	1.1	2.2	4.4	6.6	8.8	11.1	13.3	15.5	17.7
	Side or Floor	1.1	2.2	4.4	6.6	8.8	11.1	13.3	15.5	17.7
	Side Wall	2.6	5.2	10.4	15.6	20.8	26.0	31.2	36.4	41.6
2 in.	Throw	1.1	2.2	4.4	6.6	8.8	11.1	13.3	15.5	17.7
	Side or Floor	1.1	2.2	4.4	6.6	8.8	11.1	13.3	15.5	17.7
	Side Wall	3.7	7.4	14.8	22.2	29.6	37.0	44.4	51.8	59.2
2 1/2 in.	Throw	1.1	2.2	4.4	6.6	8.8	11.1	13.3	15.5	17.7
	Side or Floor	1.1	2.2	4.4	6.6	8.8	11.1	13.3	15.5	17.7
	Side Wall	4.8	9.6	19.2	28.8	38.4	48.0	57.6	67.2	76.8
3 in.	Throw	1.1	2.2	4.4	6.6	8.8	11.1	13.3	15.5	17.7
	Side or Floor	1.1	2.2	4.4	6.6	8.8	11.1	13.3	15.5	17.7
	Side Wall	5.9	11.8	23.6	35.4	47.2	59.0	70.8	82.6	94.4
3 1/2 in.	Throw	1.1	2.2	4.4	6.6	8.8	11.1	13.3	15.5	17.7
	Side or Floor	1.1	2.2	4.4	6.6	8.8	11.1	13.3	15.5	17.7
	Side Wall	7.0	14.0	28.0	42.0	56.0	70.0	84.0	98.0	112.0
4 in.	Throw	1.1	2.2	4.4	6.6	8.8	11.1	13.3	15.5	17.7
	Side or Floor	1.1	2.2	4.4	6.6	8.8	11.1	13.3	15.5	17.7
	Side Wall	8.1	16.2	32.4	48.6	64.8	81.0	97.2	113.4	129.6
5 in.	Throw	1.1	2.2	4.4	6.6	8.8	11.1	13.3	15.5	17.7
	Side or Floor	1.1	2.2	4.4	6.6	8.8	11.1	13.3	15.5	17.7
	Side Wall	9.2	18.4	36.8	55.2	73.6	92.0	110.4	128.8	147.2
6 in.	Throw	1.1	2.2	4.4	6.6	8.8	11.1	13.3	15.5	17.7
	Side or Floor	1.1	2.2	4.4	6.6	8.8	11.1	13.3	15.5	17.7
	Side Wall	10.3	20.6	41.2	61.8	82.4	103.0	123.6	144.2	164.8

Heavy Duty Mandrel Linear Bar Grille (LBMH) Core 26B/26C

Size	Static Pressure (in. w.g.)	0.012	0.026	0.048	0.076	0.107	0.146	0.191	0.242	0.3
1 1/2 in.	Throw	1.1	2.2	4.4	6.6	8.8	11.1	13.3	15.5	17.7
	Side or Floor	1.1	2.2	4.4	6.6	8.8	11.1	13.3	15.5	17.7
	Side Wall	2.8	5.6	11.2	16.8	22.4	28.0	33.6	39.2	44.8
	Flow Rate (cfm)	19	29	39	49	59	69	79	89	99
2 in.	Throw	1.1	2.2	4.4	6.6	8.8	11.1	13.3	15.5	17.7
	Side or Floor	1.1	2.2	4.4	6.6	8.8	11.1	13.3	15.5	17.7
	Side Wall	3.9	7.8	15.6	23.4	31.2	39.0	46.8	54.6	62.4
	Flow Rate (cfm)	28	40	53	66	79	92	105	118	132
2 1/2 in.	Throw	1.1	2.2	4.4	6.6	8.8	11.1	13.3	15.5	17.7
	Side or Floor	1.1	2.2	4.4	6.6	8.8	11.1	13.3	15.5	17.7
	Side Wall	5.0	10.0	20.0	30.0	40.0	50.0	60.0	70.0	80.0
	Flow Rate (cfm)	36	54	72	90	108	126	144	162	180
3 in.	Throw	1.1	2.2	4.4	6.6	8.8	11.1	13.3	15.5	17.7
	Side or Floor	1.1	2.2	4.4	6.6	8.8	11.1	13.3	15.5	17.7
	Side Wall	6.1	12.2	24.4	36.6	48.8	61.0	73.2	85.4	97.6
	Flow Rate (cfm)	42	63	84	106	126	146	166	186	210
3 1/2 in.	Throw	1.1	2.2	4.4	6.6	8.8	11.1	13.3	15.5	17.7
	Side or Floor	1.1	2.2	4.4	6.6	8.8	11.1	13.3	15.5	17.7
	Side Wall	8.2	16.4	32.8	49.2	65.6	82.0	98.4	114.8	131.2
	Flow Rate (cfm)	50	75	100	125	150	175	200	225	250
4 in.	Throw	1.1	2.2	4.4	6.6	8.8	11.1	13.3	15.5	17.7
	Side or Floor	1.1	2.2	4.4	6.6	8.8	11.1	13.3	15.5	17.7
	Side Wall	10.4	20.8	41.6	62.4	83.2	104.0	124.8	145.6	166.4
	Flow Rate (cfm)	60	90	120	150	180	210	240	270	300
5 in.	Throw	1.1	2.2	4.4	6.6	8.8	11.1	13.3	15.5	17.7
	Side or Floor	1.1	2.2	4.4	6.6	8.8	11.1	13.3	15.5	17.7
	Side Wall	12.6	25.2	50.4	75.6	100.8	126.0	151.2	176.4	201.6
	Flow Rate (cfm)	66	99	132	165	198	231	264	297	330
6 in.	Throw	1.1	2.2	4.4	6.6	8.8	11.1	13.3	15.5	17.7
	Side or Floor	1.1	2.2	4.4	6.6	8.8	11.1	13.3	15.5	17.7
	Side Wall	14.8	29.6	59.2	88.8	118.4	148.0	177.6	207.2	236.8
	Flow Rate (cfm)	72	108	144	180	216	252	288	324	360
8 in.	Throw	1.1	2.2	4.4	6.6	8.8	11.1	13.3	15.5	17.7
	Side or Floor	1.1	2.2	4.4	6.6	8.8	11.1	13.3	15.5	17.7
	Side Wall	17.0	34.0	68.0	102.0	136.0	170.0	204.0	238.0	272.0
	Flow Rate (cfm)	90	135	180	225	270	315	360	405	450

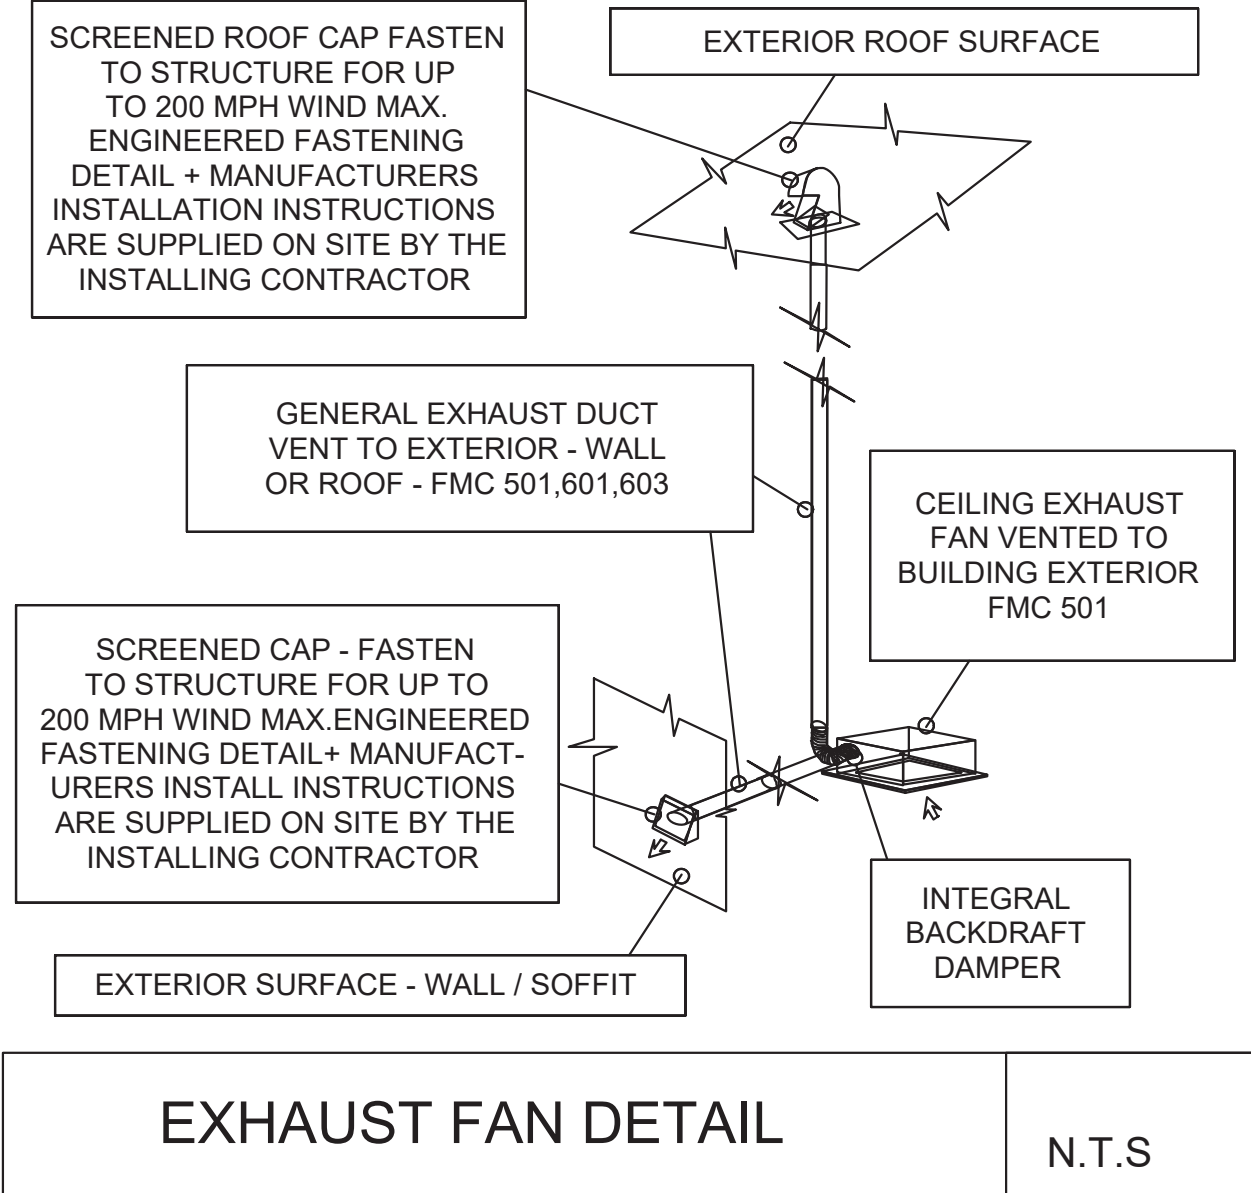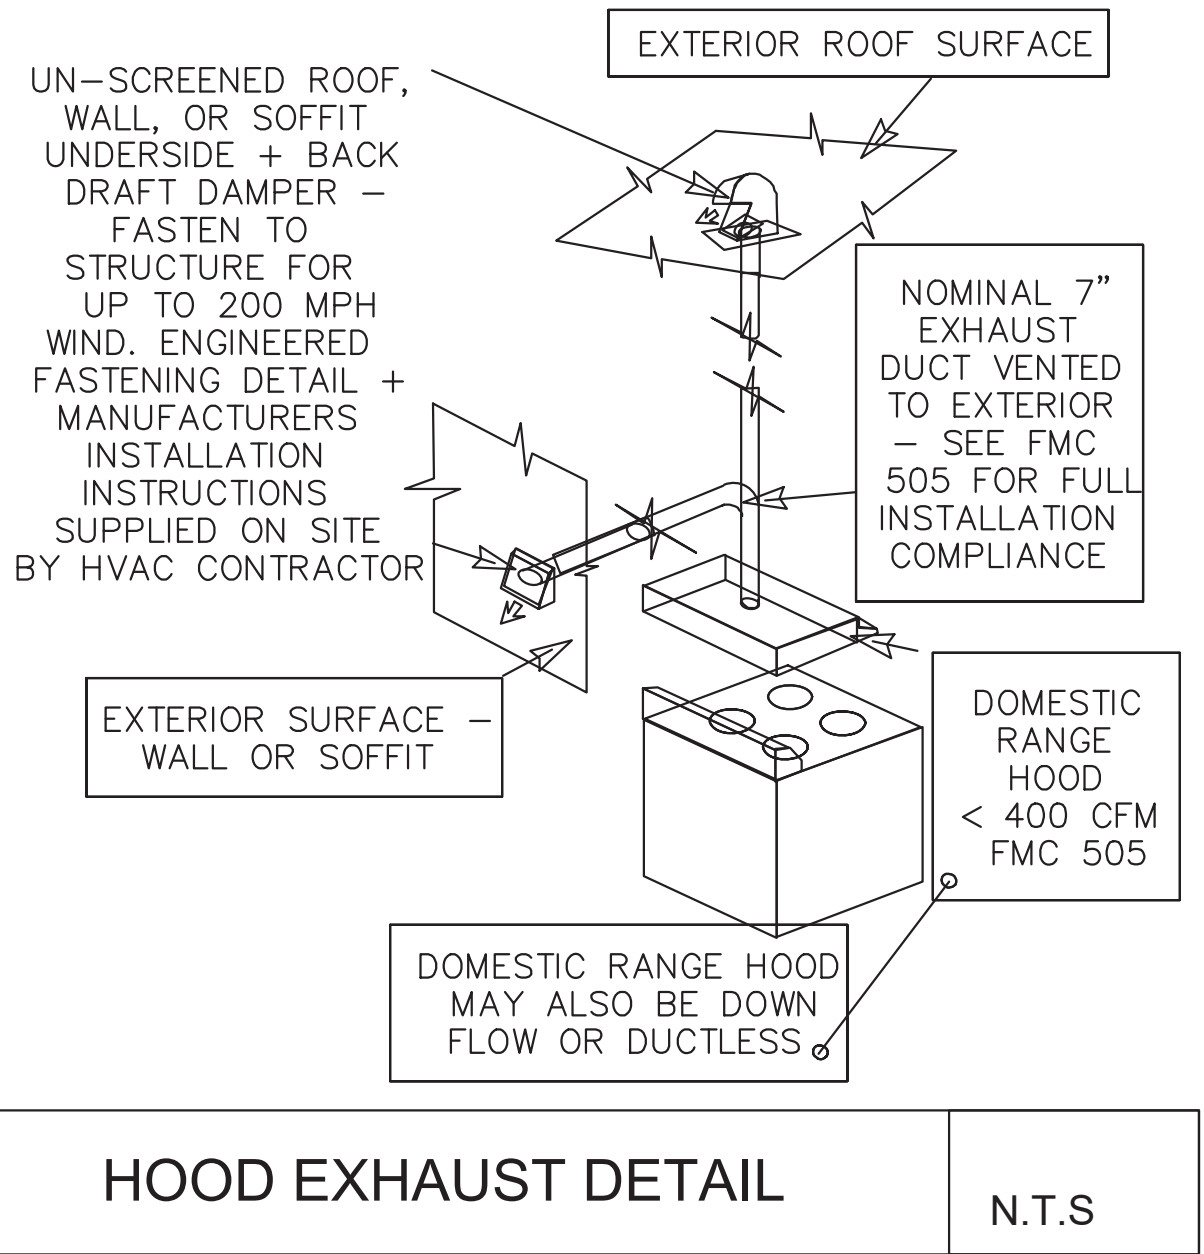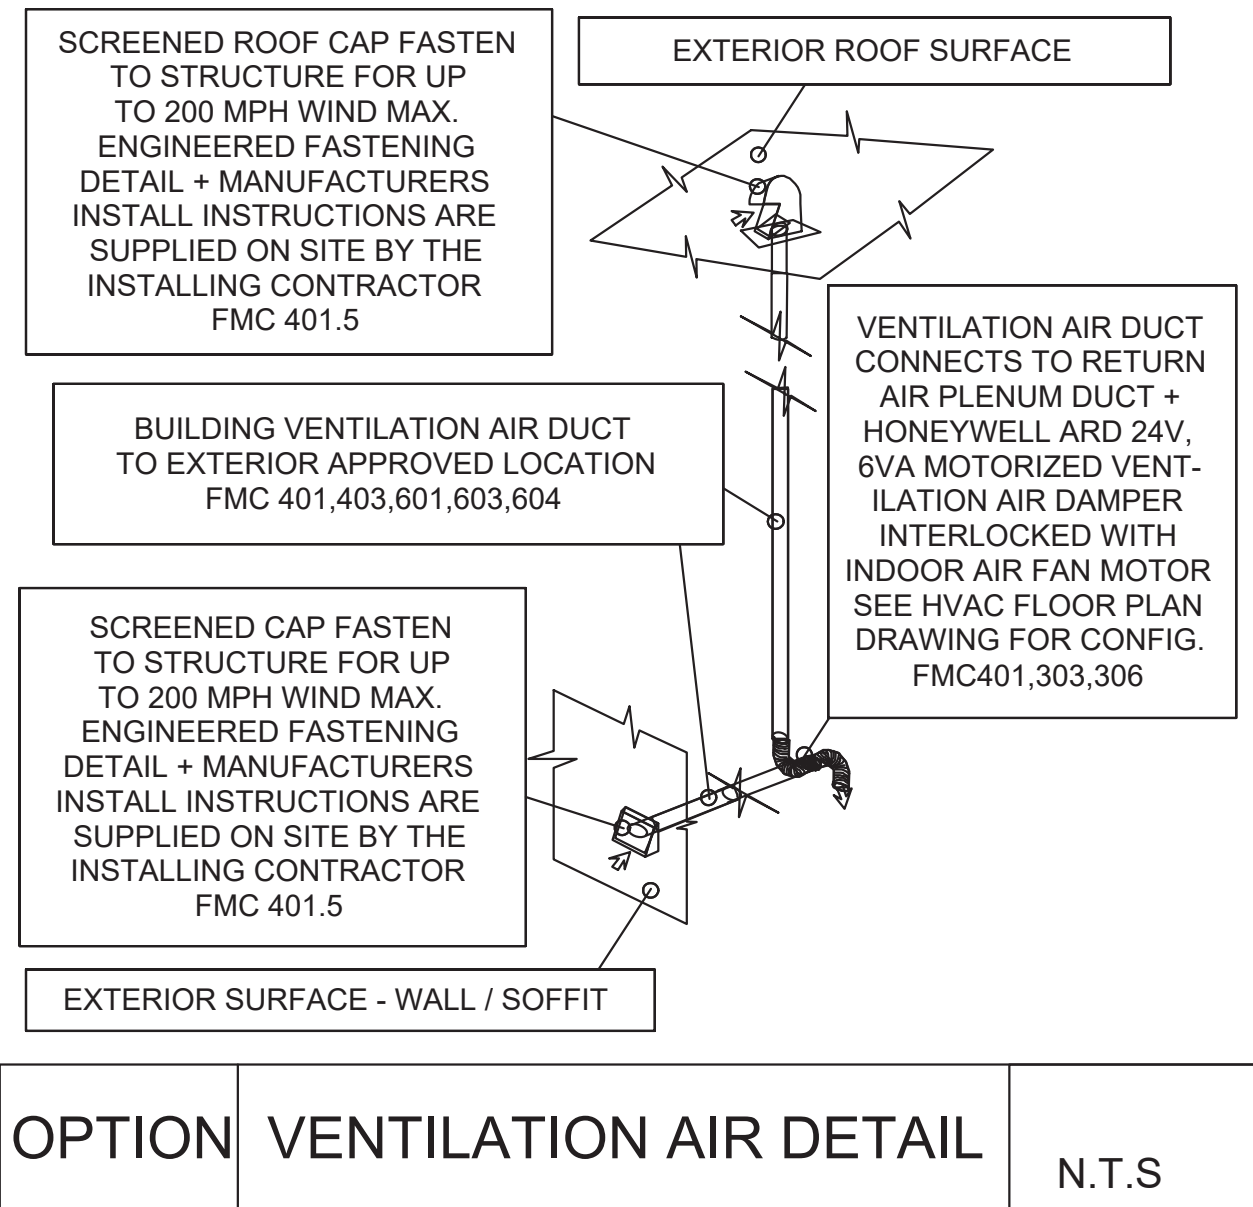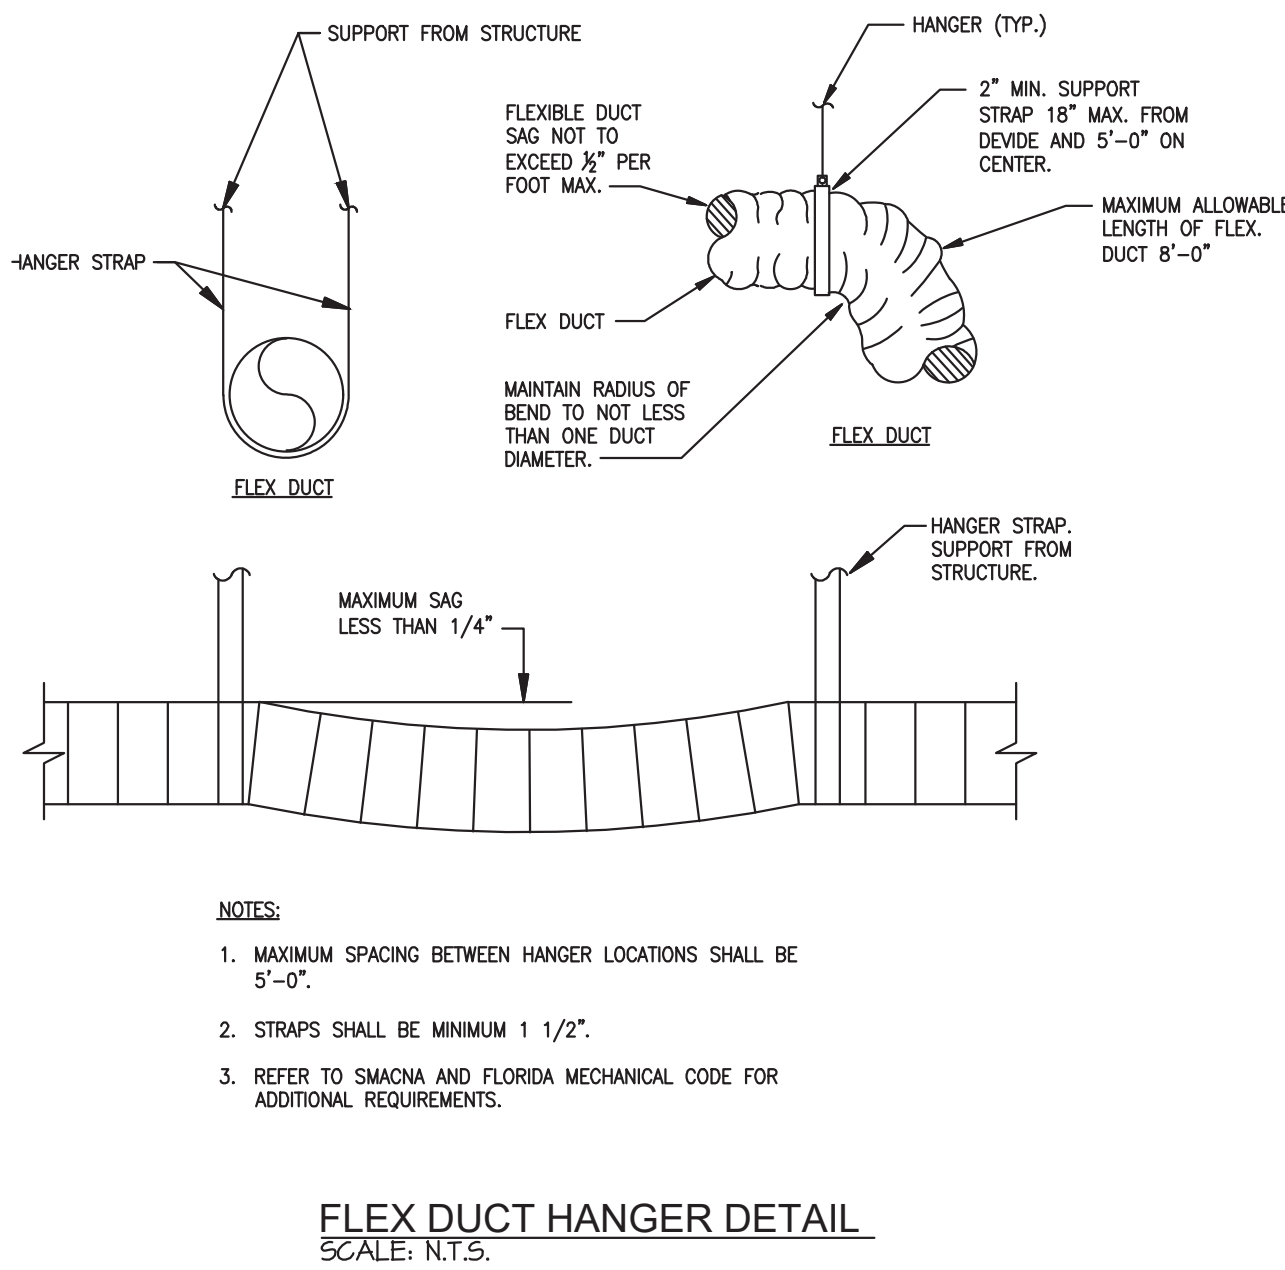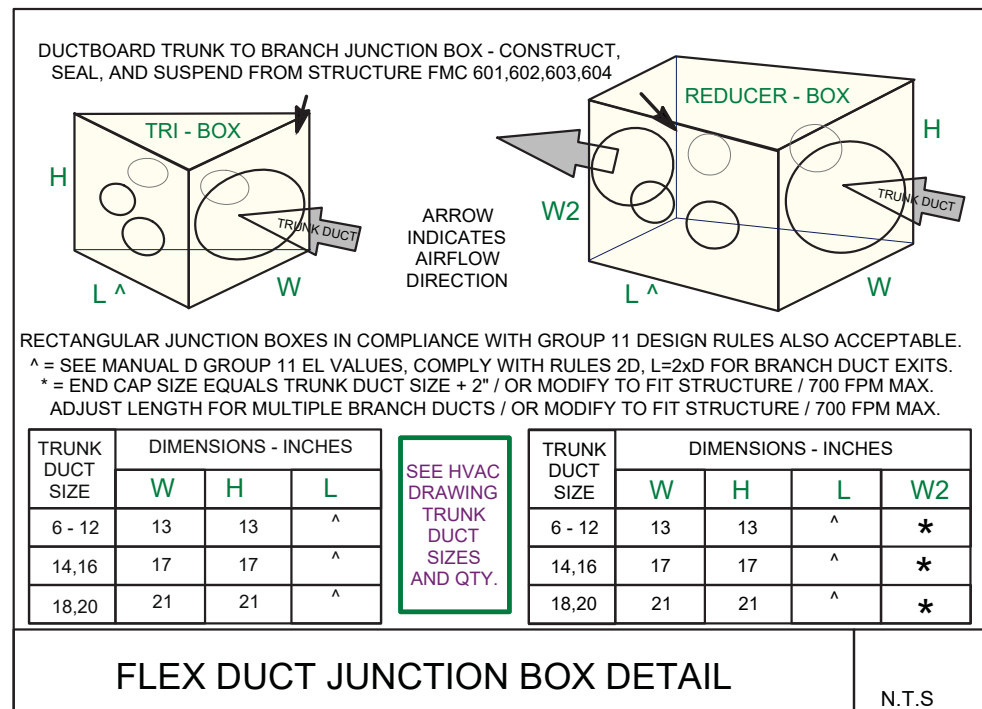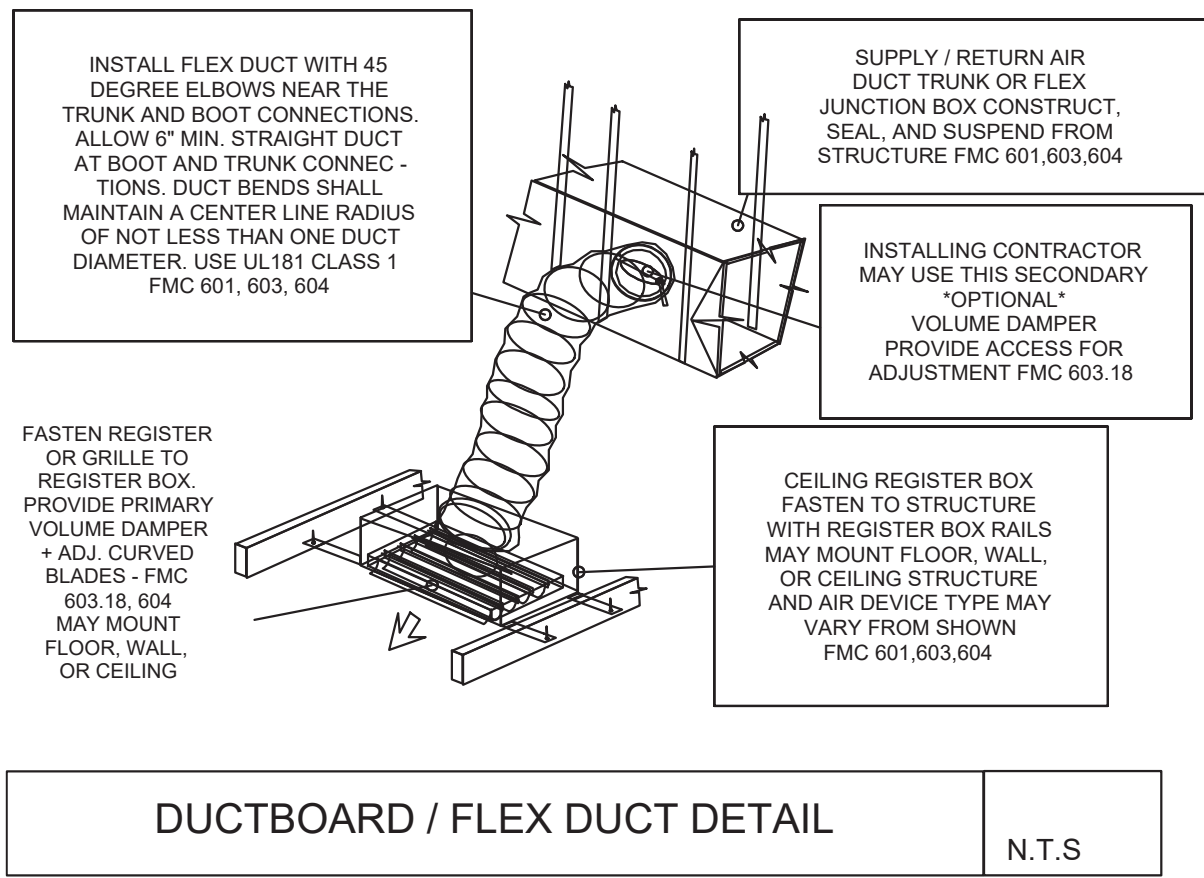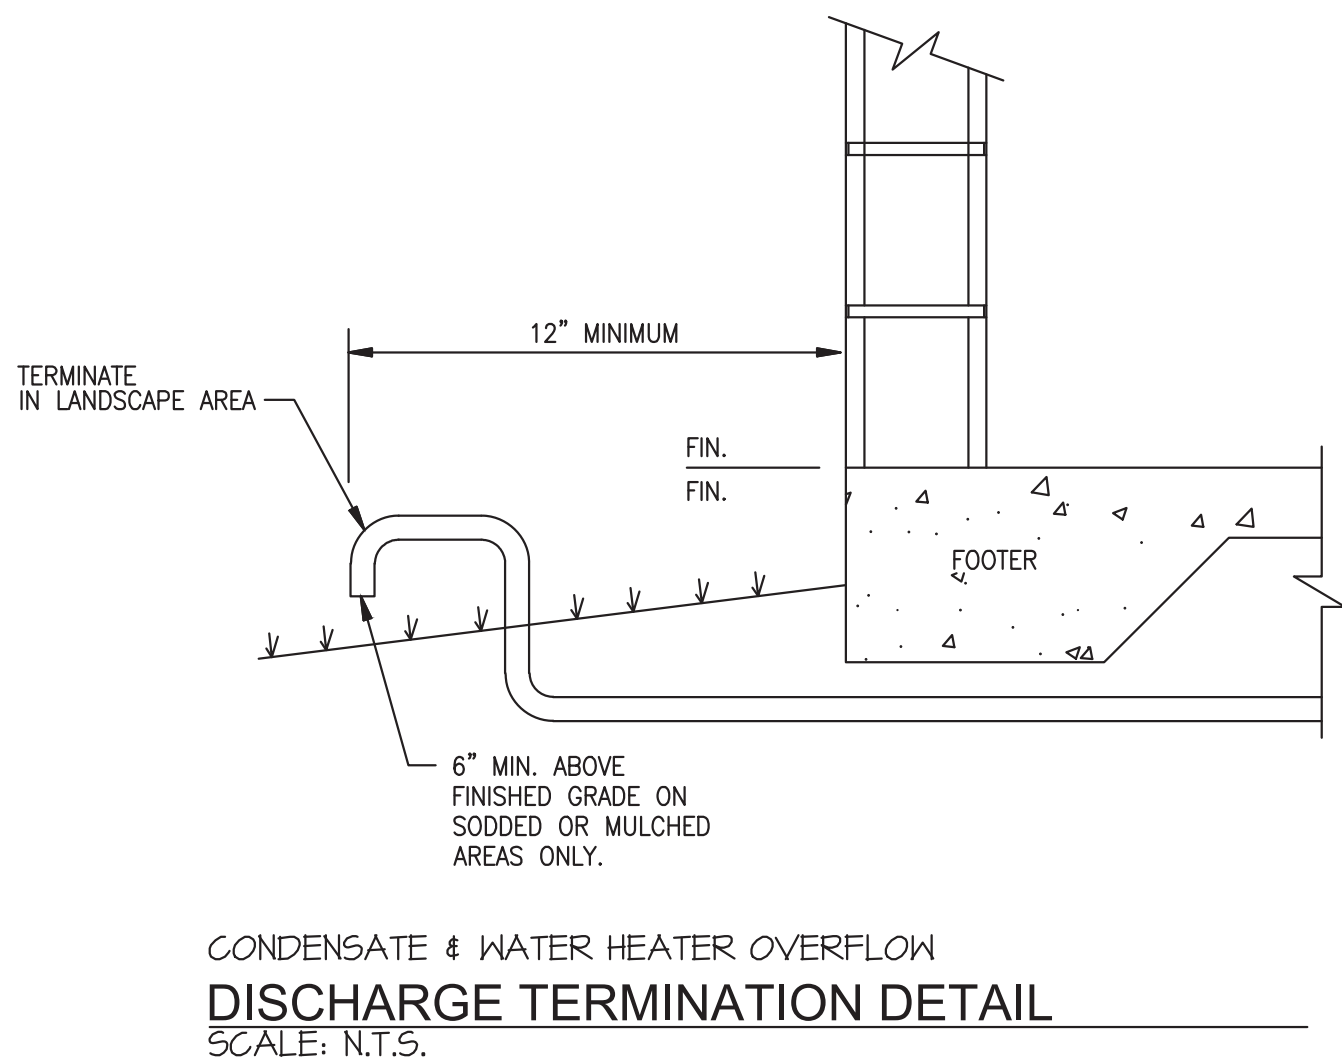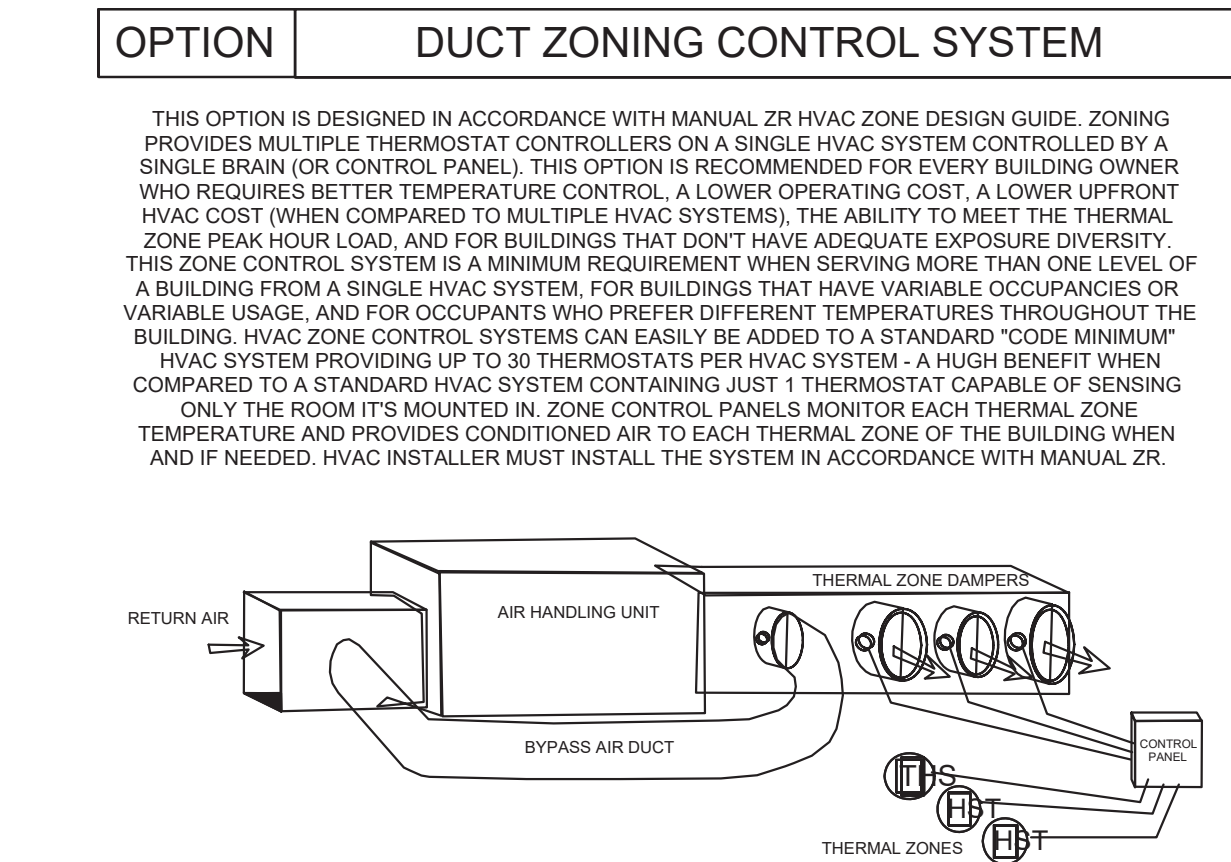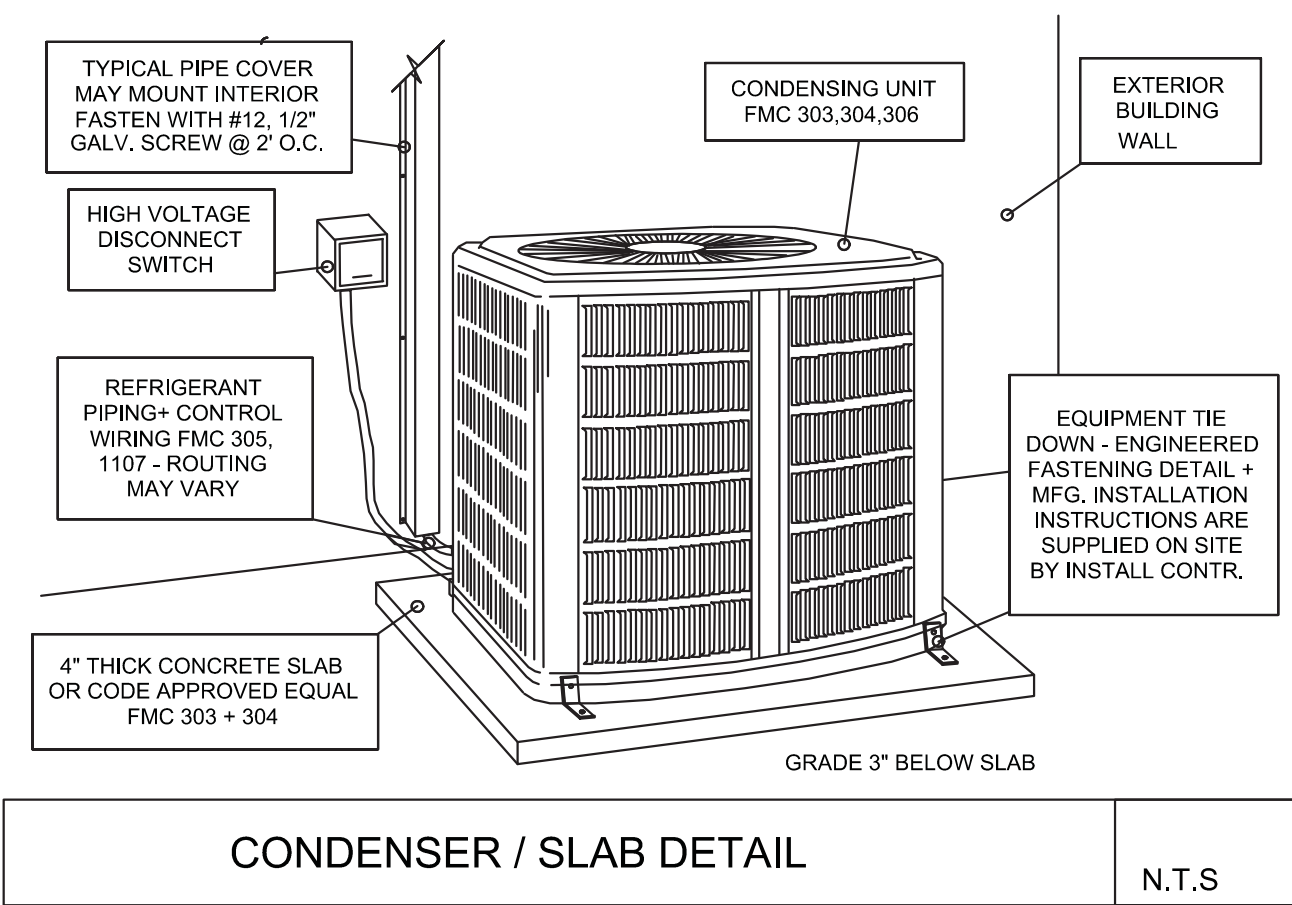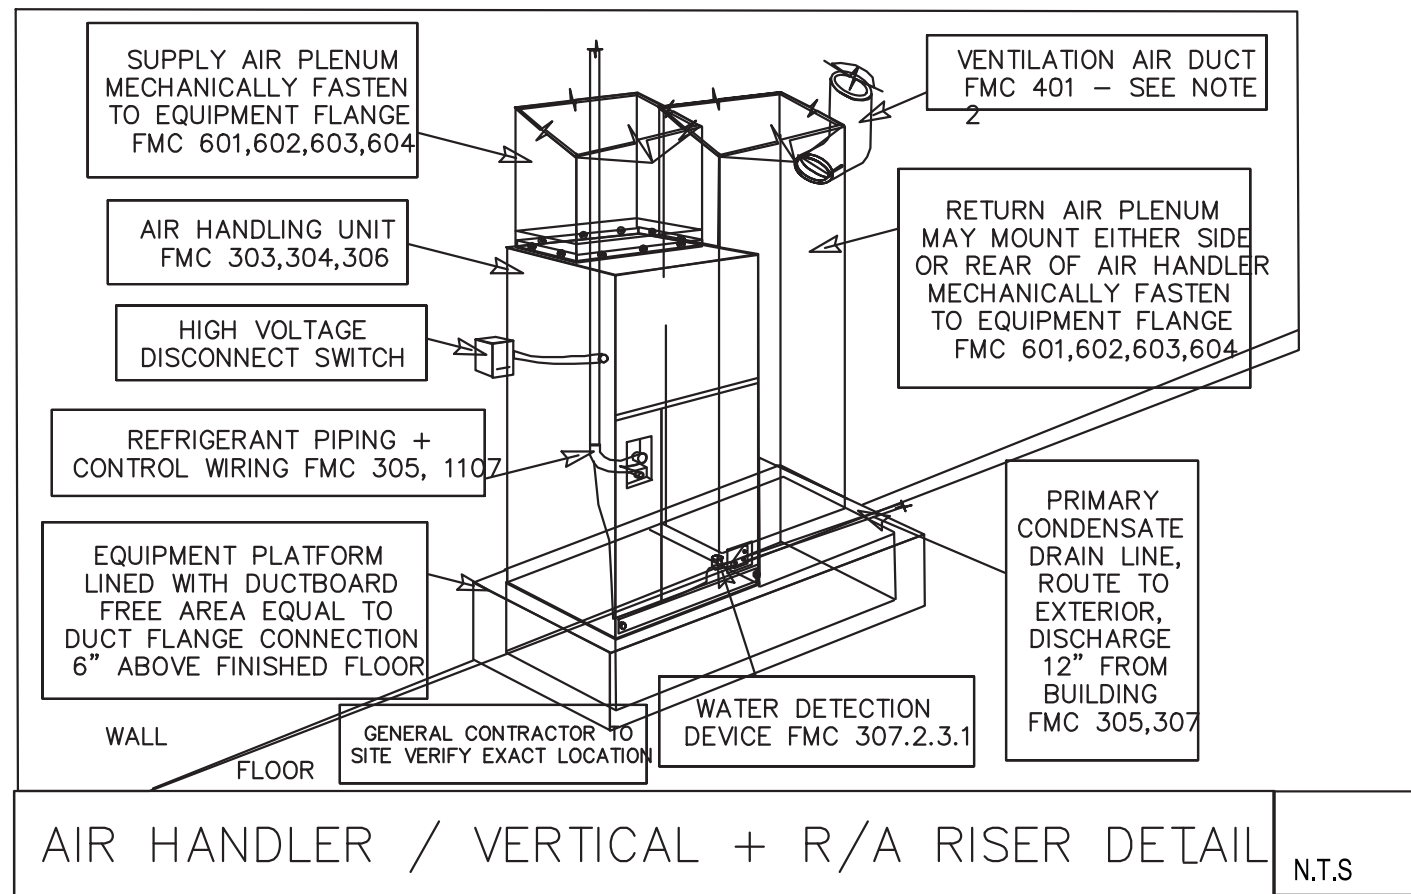

ALL THE DESIGN AND DETAILS ON THIS PLAN ARE THE PROPERTY OF LIGHTNING ENGINEERING. THEY ARE NOT TO BE USED, COPIED OR REPRODUCED WITHOUT THE WRITTEN PERMISSION OF LIGHTNING ENGINEERING.

I HEREBY CERTIFY AS THE BUILDING DESIGN ENGINEER OF RECORD, THAT THE BUILDING DESIGN AS SHOWN ON THESE PLANS AND SPECIFICATIONS IS THE PROPERTY OF LIGHTNING ENGINEERING. I HAVE REVIEWED THE PLANS AND SPECIFICATIONS AND CERTIFY THAT THEY COMPLY WITH THE BUILDING CODE. THIS CERTIFICATION DOES NOT INCLUDE ROOF TRUSS COMPONENTS OR ROOF STRUCTURE. I HAVE REVIEWED THE ROOF TRUSS COMPONENTS AND ROOF STRUCTURE AND CERTIFY THAT THEY COMPLY WITH THE BUILDING CODE. THIS PLAN HAS BEEN PREPARED IN COMPLIANCE WITH THE BUILDING CODE WITH SUPPLEMENTS.

4161 TAMiami TRAIL UNIT 101
FORT CHARLOTTE, FL 33980
TEL 813-978-8195
FAX 813-978-8195



NOVA PARKS
46442 PARK CHALET PL, STERLING, VIRGINIA, 20165
MARC O'GRADY DESIGN

PROJECT NAME
& ADDRESS:

No.	Description	Date
1		
2		
3		
4		

DRAWN BY: PLC

REVISED BY: JPP

PROJECT NO: 26 173 78

SHEET TITLE:

MECHANICAL
DETAILS

SHEET NUMBER:


MD-100

PLUMBING LEGEND		Water Supply Fixture Units					
	DCW--DOMESTIC COLD WATER						
	DHW--DOMESTIC HOT WATER						
	DHC--DOMESTIC HOT WATER RECIRCULATION						
	WATER VALVE						
	RECIRCULATION PUMP						
Predominant Supply Systems:		Flush Tank	Input Cells				
		Flushometer/Valve					
Tag	Pipe Size	Fixture Type	Occupancy	Type of Supply Control	Number of Fixtures	Load Value	WSFU
		2 Full-Bath Group	Private	Flush Tank	2	3.60	7.20
HB	1/2	Hose Bib	Private	Faucet	1	0.25	0.25
REF	1/2	Refrigerator	Private	Faucet	1	0.25	0.25
DW	1/2	Dishwashing Machine	Private	Automatic	1	1.40	1.40
S	1/2	Kitchen Sink	Private	Faucet	1	1.40	1.40
Total WSFU:							10.50
Domestic Demand ¹ :							15.00 GPM
NOTES							
1- PIPE SIZE (INCH)							


PLUMBING WATER HEATER (ELECTRICAL) SCHEDULE									
TAG	ELECTRICAL DATA			HYDRONIC REQUIREMENTS		BASIS OF DESIGN*		OPERATING	
	MCA AMPS	MOCP AMPS	VOLTAGE	STORAGE GALLONS	CAPACITY LBS	MANUFACTURER	MODEL OR SERIES	WEIGHT LBS	NOTES
WH	24	30	240/1/60	50		RHEEM	ES50-6	320	

* OR SIMILAR MANUFACTURER

NOTES LEGEND	
	CONNECT TO EXISTING DCW LINE.

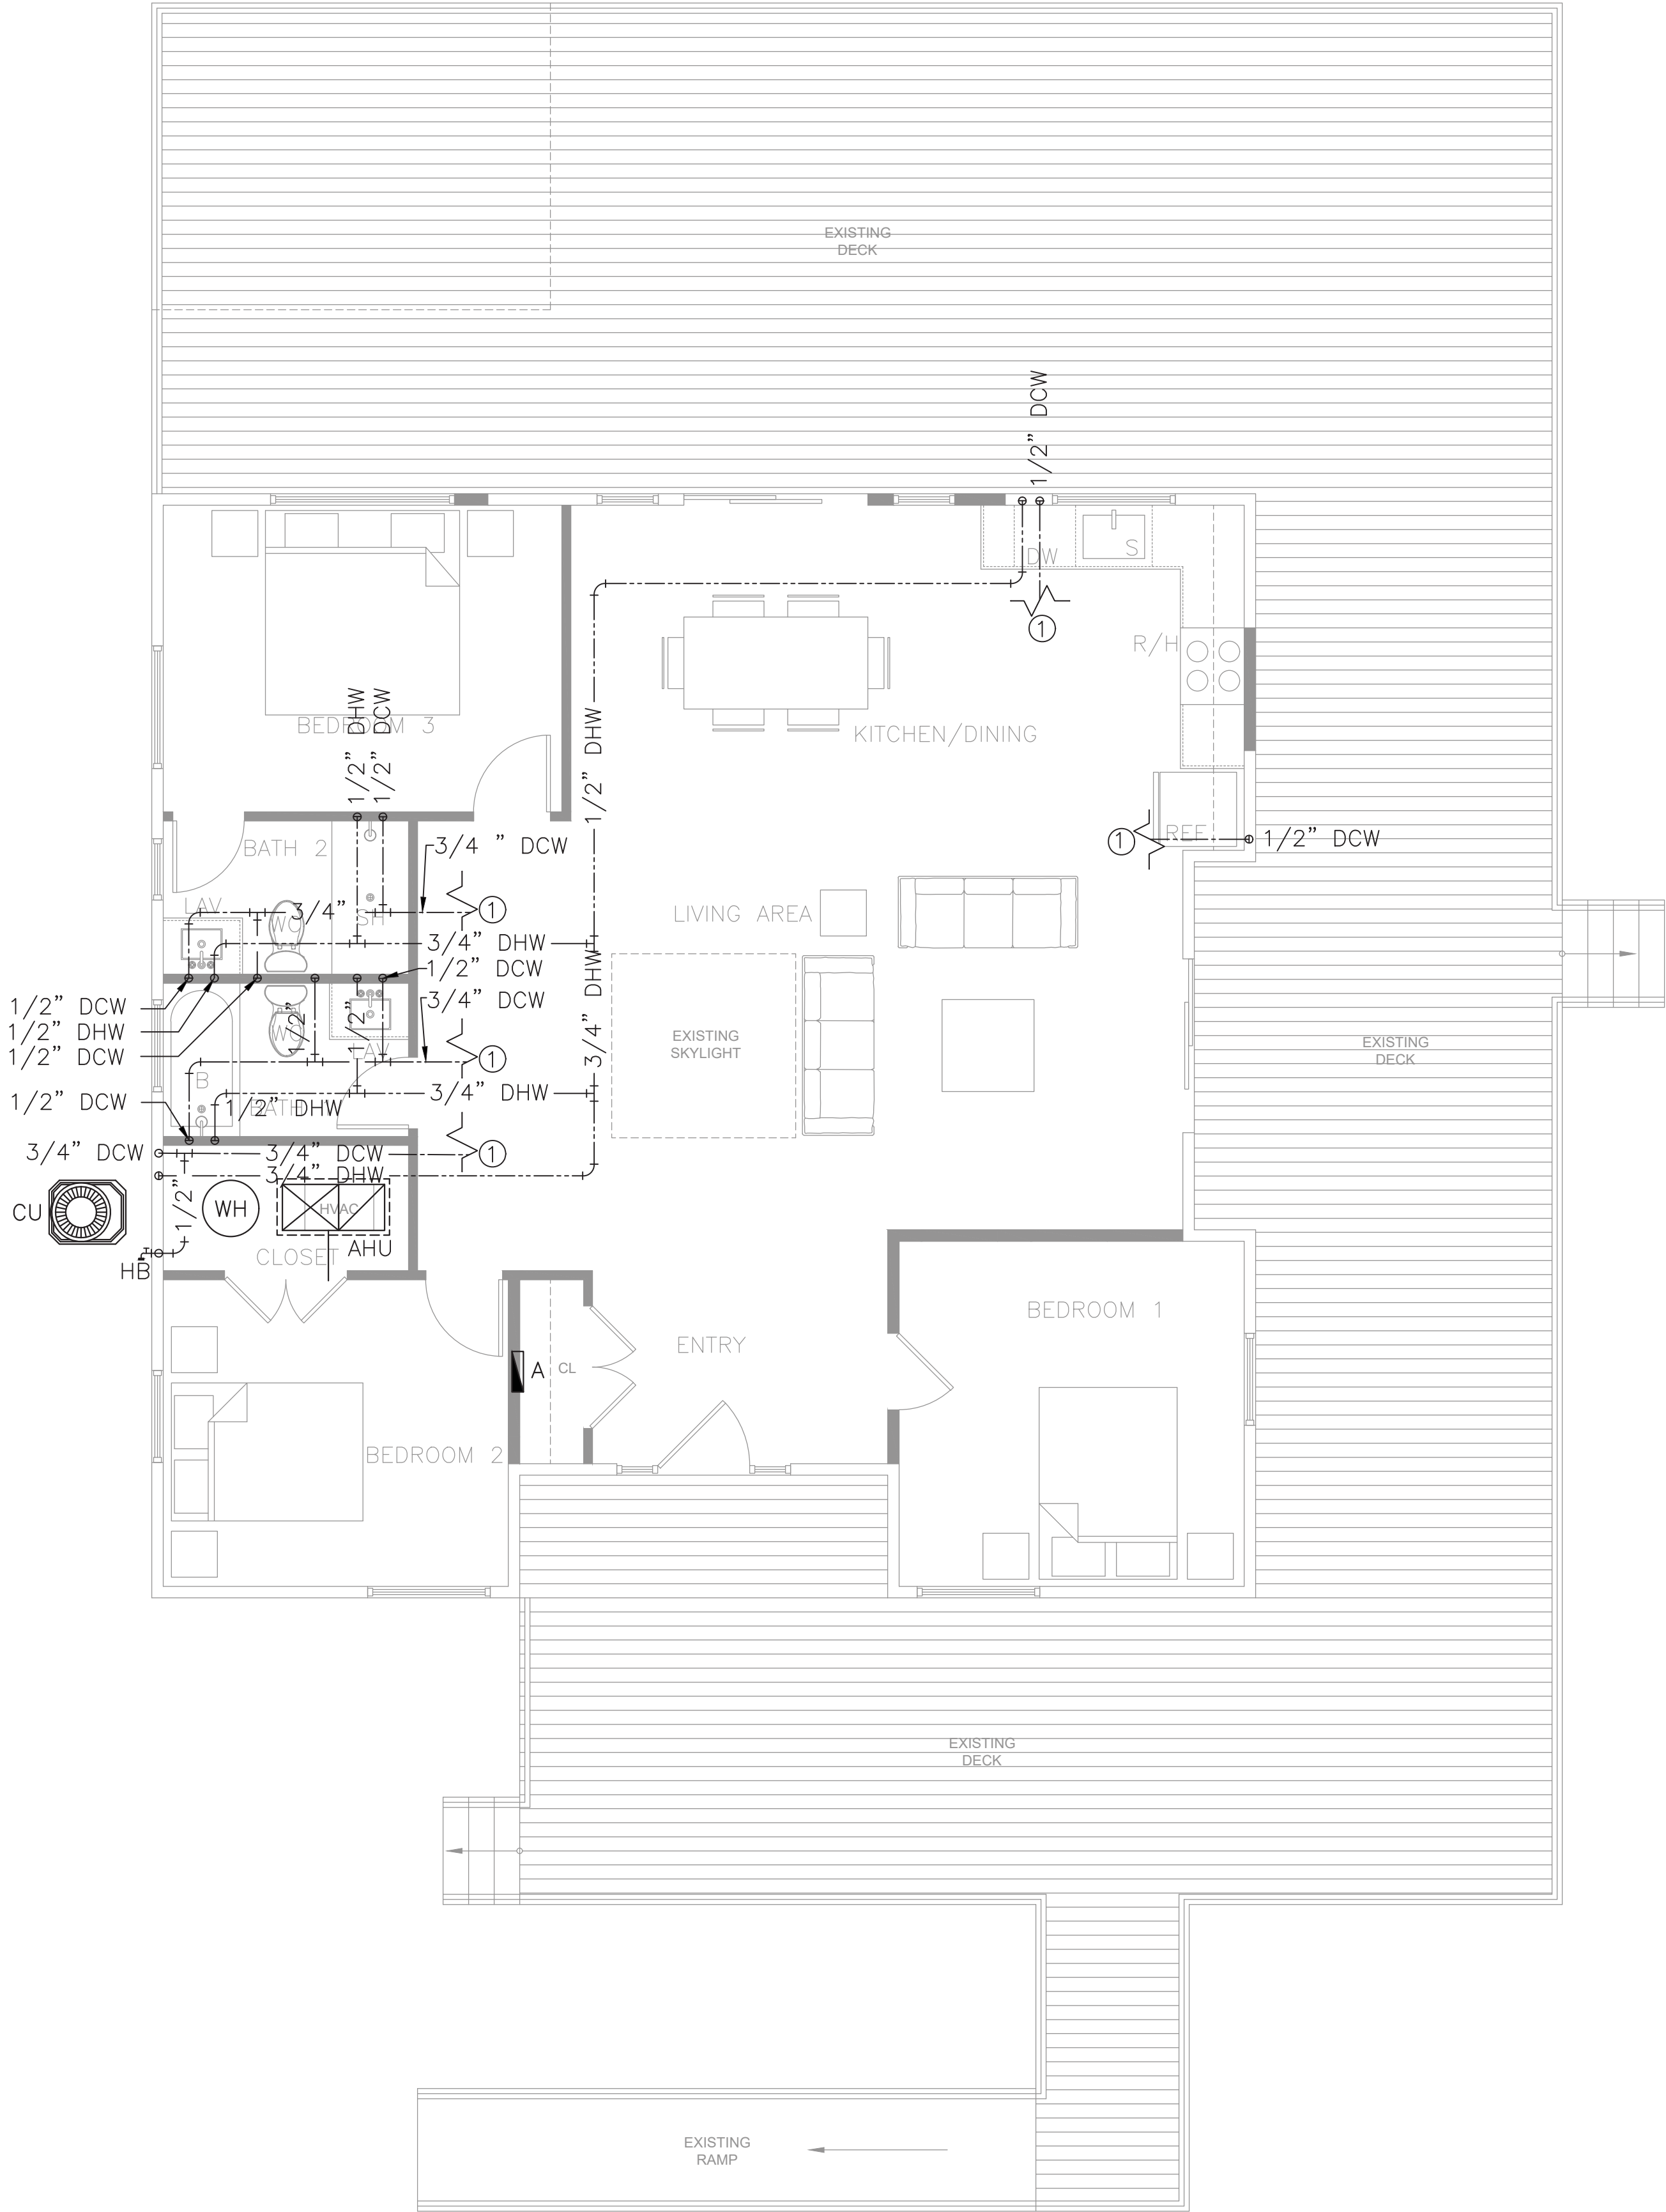

DOMESTIC WATER PLAN
1/4" = 1'-0"

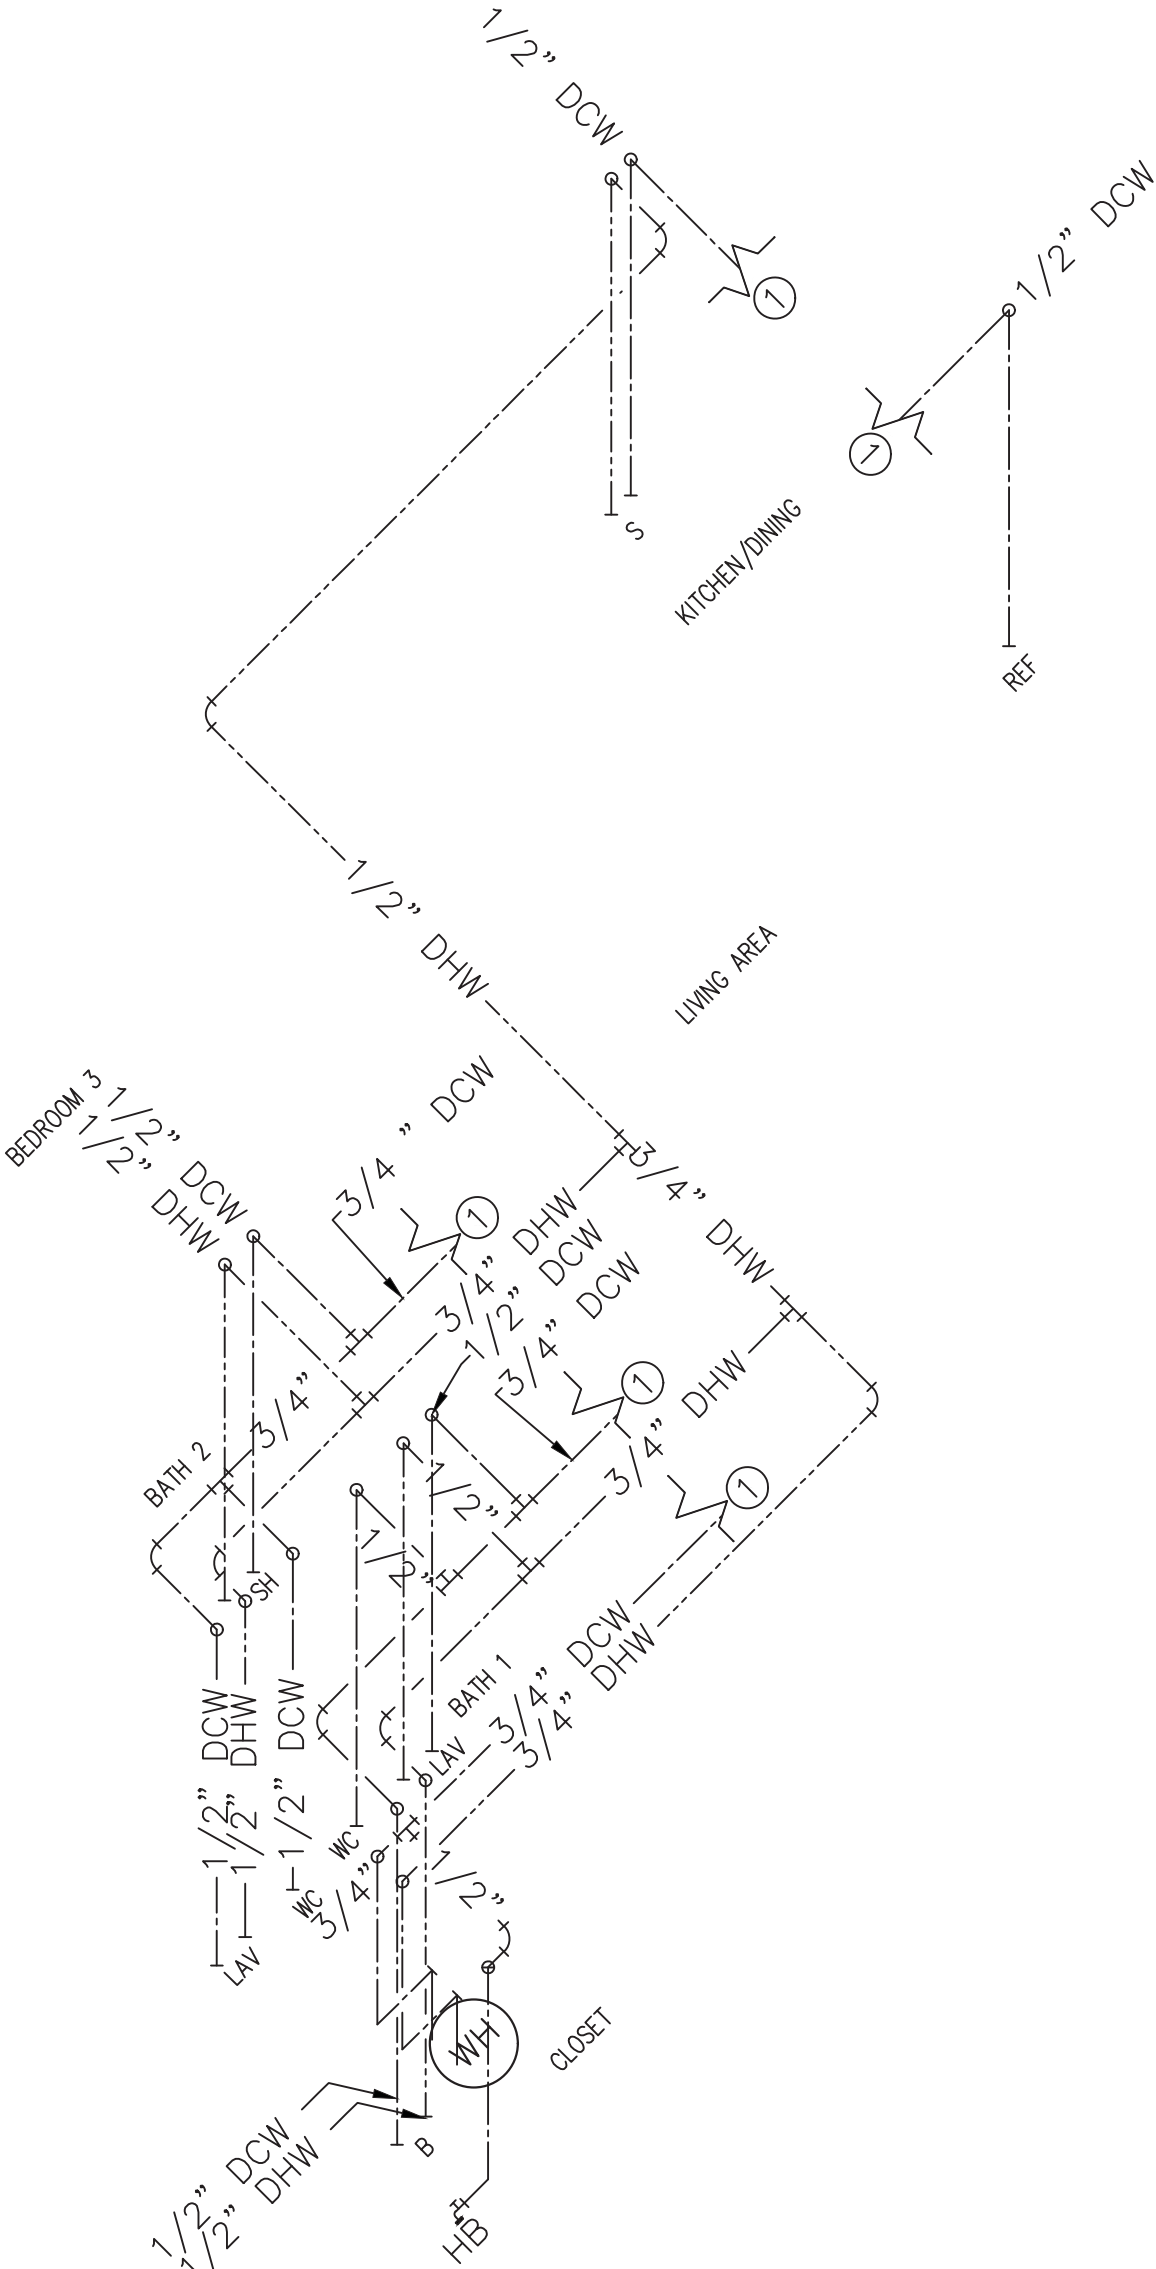

DOMESTIC WATER ISOMETRIC VIEW
N.T.S

ALL THE DESIGN AND DETAILS ON THIS PLAN ARE THE PROPERTY OF LIGHTNING ENGINEERING AND SHALL NOT BE USED, COPIED OR REPRODUCED WITHOUT THE WRITTEN PERMISSION OF LIGHTNING ENGINEERING.

I HEREBY CERTIFY AS THE BUILDING DESIGN ENGINEER OF RECORD, THAT THE BUILDING DESIGN AS SHOWN ON THESE PLANS AND SPECIFICATIONS IS THE DESIGN OF THE ENGINEER AND THAT THE DESIGN OF THE BUILDING IS IN ACCORDANCE WITH THE BUILDING CODE OF RECORD. THIS PLAN HAS BEEN PREPARED IN COMPLIANCE WITH THE BUILDING CODE WITH SUPPLEMENTS.

4161 TAMiami TRAIL UNIT 101
PORT CHARLOTTE, FL 33980
TEL: 813-978-8195
FAX: 813-978-8195



PROJECT NAME
& ADDRESS:


NOVA PARKS
46442 PARK CHALET PL, STERLING, VIRGINIA, 20165
MARC O'GRADY DESIGN

No.	Description	Date


DRAWN BY:	PLC
REVISED BY:	JPP
PROJECT NO:	26 173 78
SHEET TITLE:	

PLUMBING
PLAN


SHEET NUMBER:
P-100

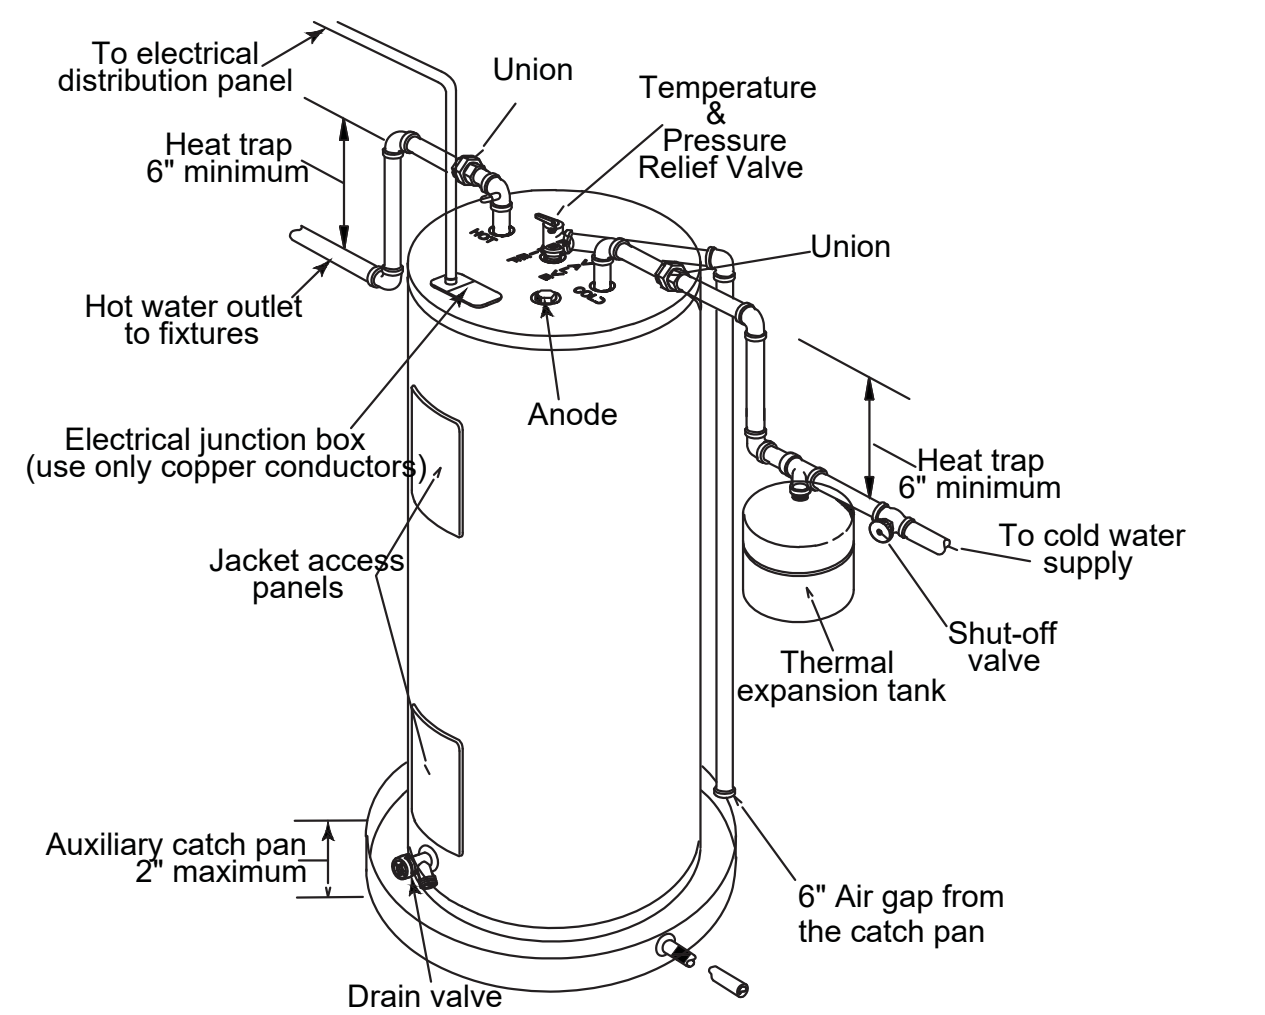


TYPICAL WATER HEATER DETAIL
SCALE: N.T.S.

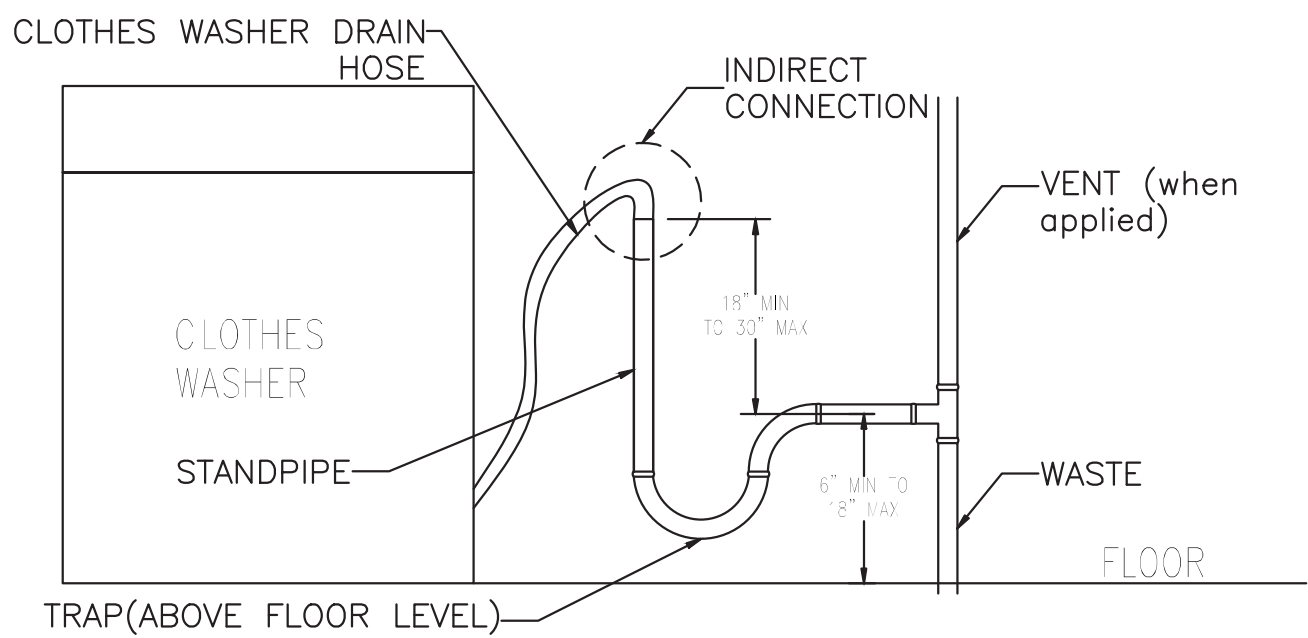


WASHER INDIRECT DRAIN CONNECTION
SCALE: N.T.S.
PROVIDE STANDPIPE IN ALL CLOTHES WASHER MACHINE.

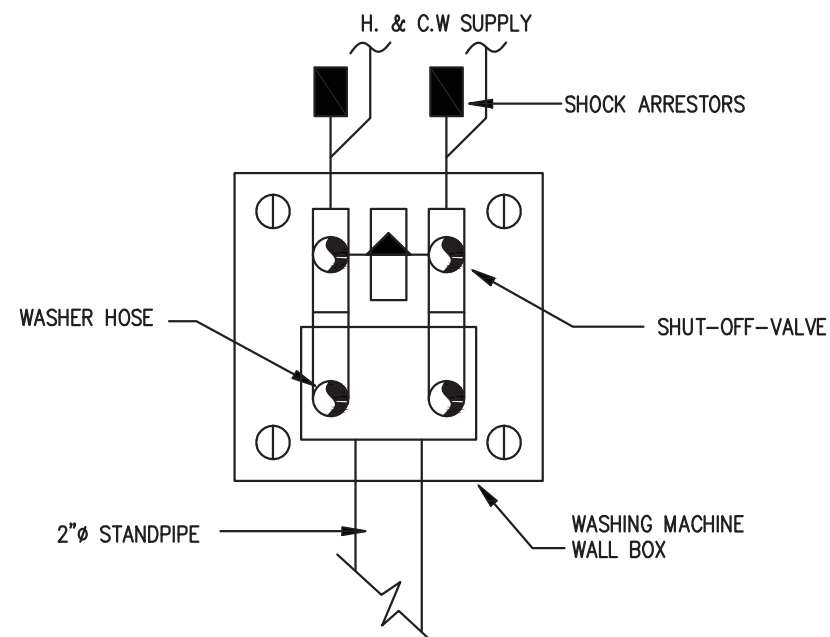

WASHER MACHINE BOX DETAIL
SCALE: N.T.S.

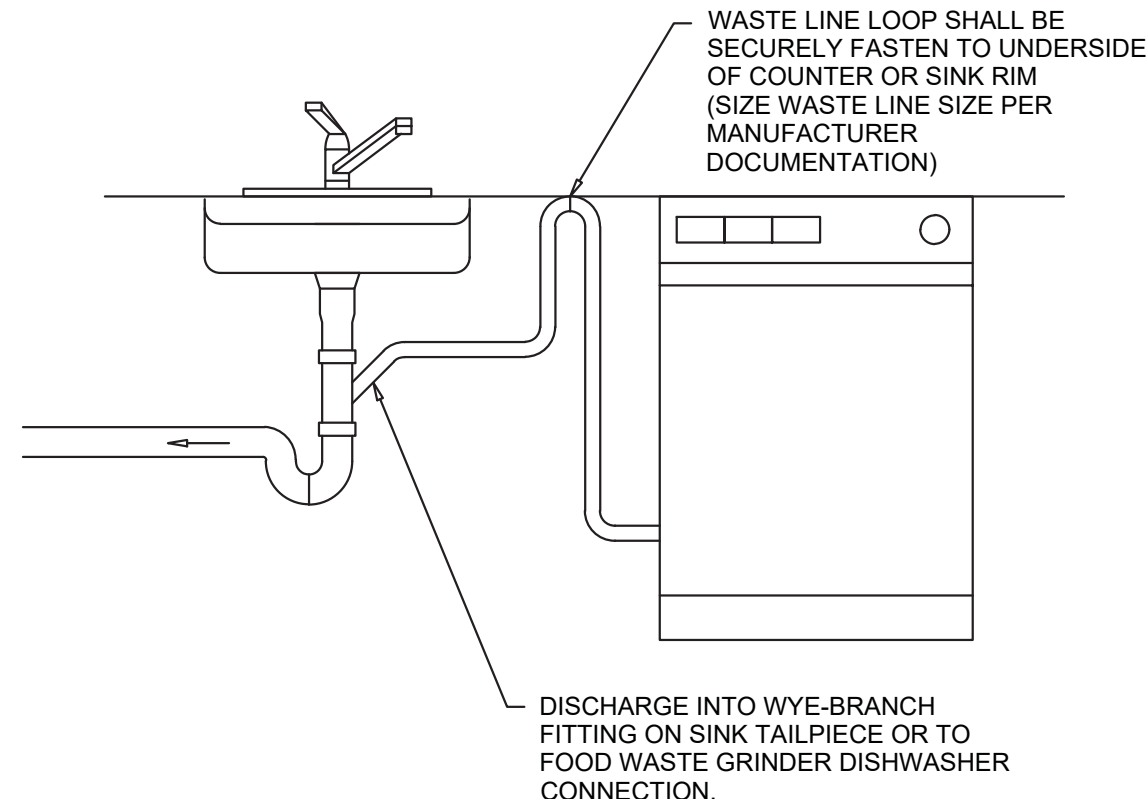


RESIDENTIAL DISHWASHER WASTE CONNECTION
N.T.S.

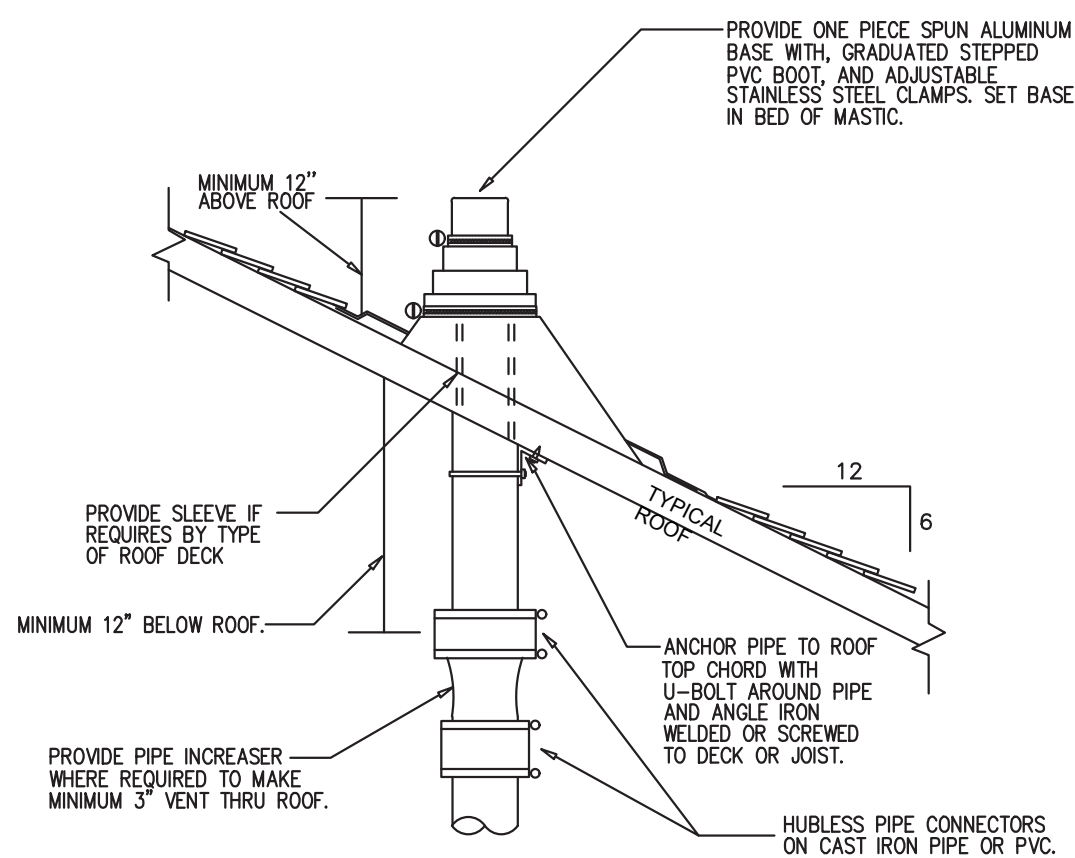


REFER TO PLANS FOR VTR PIPE SIZES AND LOCATIONS. LOCATE VENT THRU ROOF MINIMUM TEN FEET HORIZONTAL OR THREE FEET VERTICAL ABOVE ANY BUILDING OPENING OR FRESH AIR INTAKE, AND ONE FOOT FROM ANY VERTICAL SURFACE. PROVIDE 1" FIBERGLASS INSULATION WITH ALL-SERVICE JACKET ON VENT PIPE INSIDE BUILDING WITHIN SIX FEET OF VENT THRU ROOF LOCATION. VERIFY FLASHING AND COUNTER FLASH WITH ROOFING CONTRACTOR.

VENT THRU ROOF (VTR) DETAIL

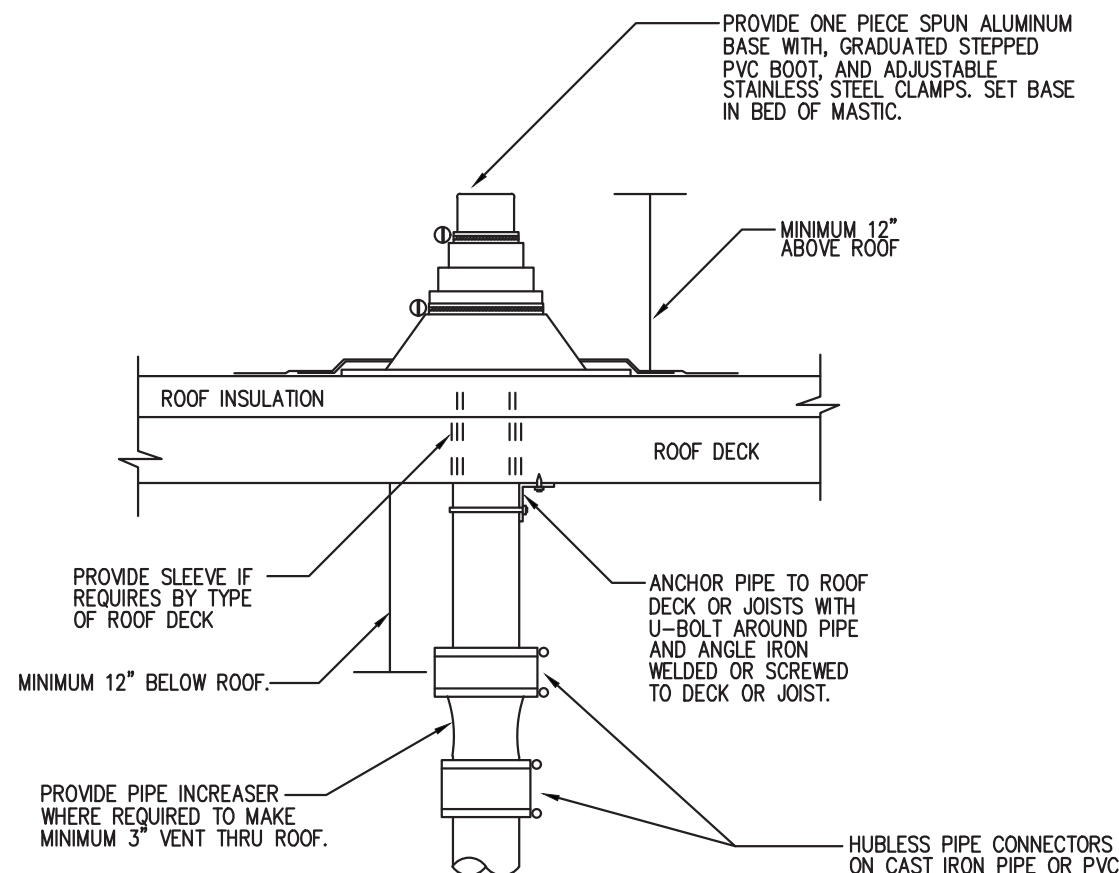


REFER TO PLANS FOR VTR PIPE SIZES AND LOCATIONS. LOCATE VENT THRU ROOF MINIMUM TEN FEET HORIZONTAL OR THREE FEET VERTICAL ABOVE ANY BUILDING OPENING OR FRESH AIR INTAKE, AND ONE FOOT FROM ANY VERTICAL SURFACE. PROVIDE 1" FIBERGLASS INSULATION WITH ALL-SERVICE JACKET ON VENT PIPE INSIDE BUILDING WITHIN SIX FEET OF VENT THRU ROOF LOCATION. VERIFY FLASHING AND COUNTER FLASH WITH ROOFING CONTRACTOR.


VENT THRU ROOF (VTR) DETAIL

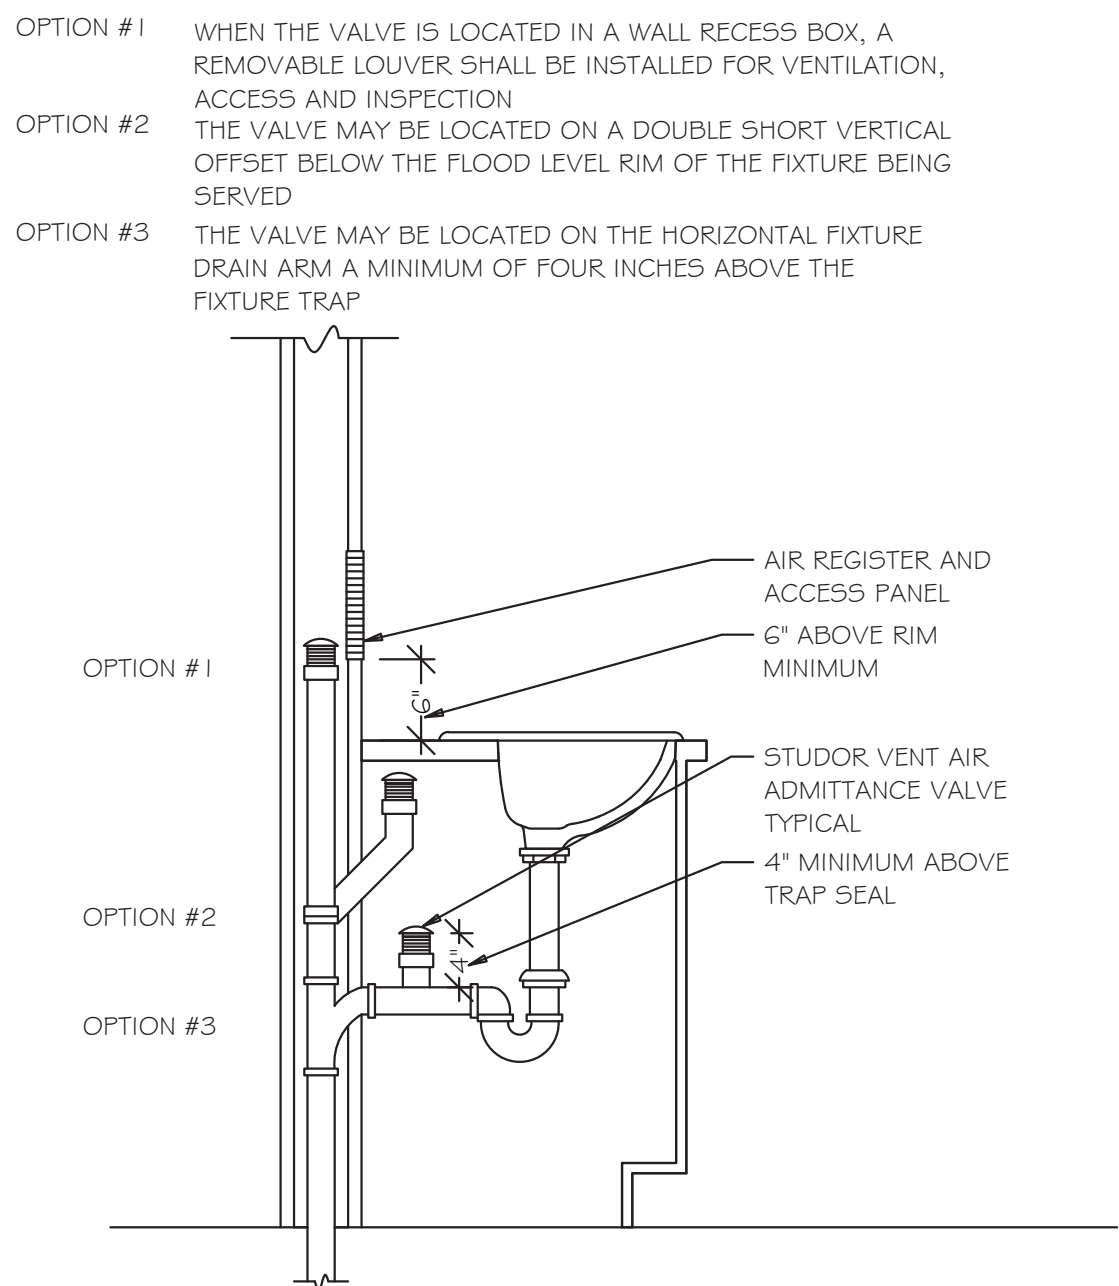


AIR ADMITTANCE VALVE (AAV) DETAIL
N.T.S.

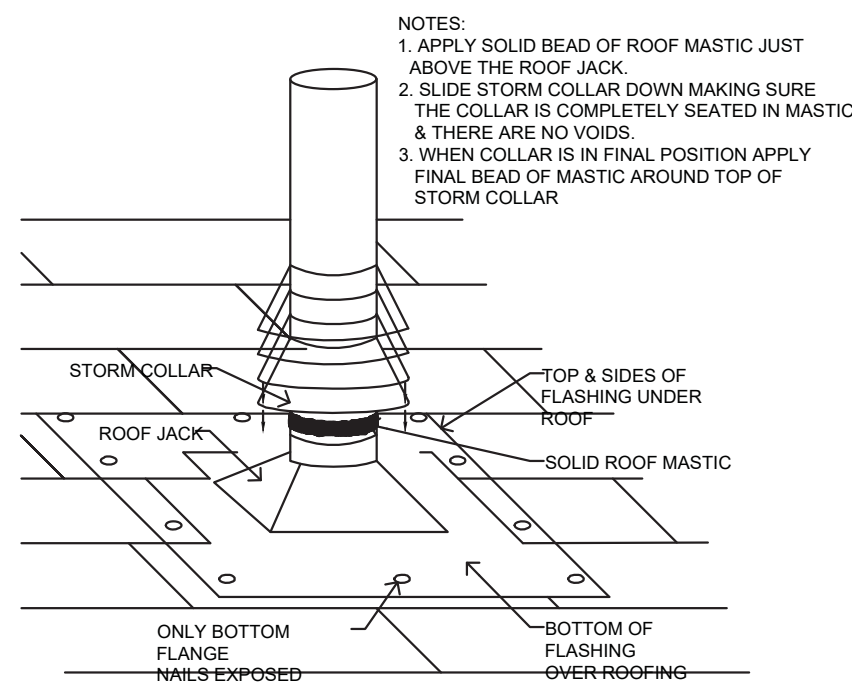


VENT PIPE PENETRATION
SCALE: N.T.S.

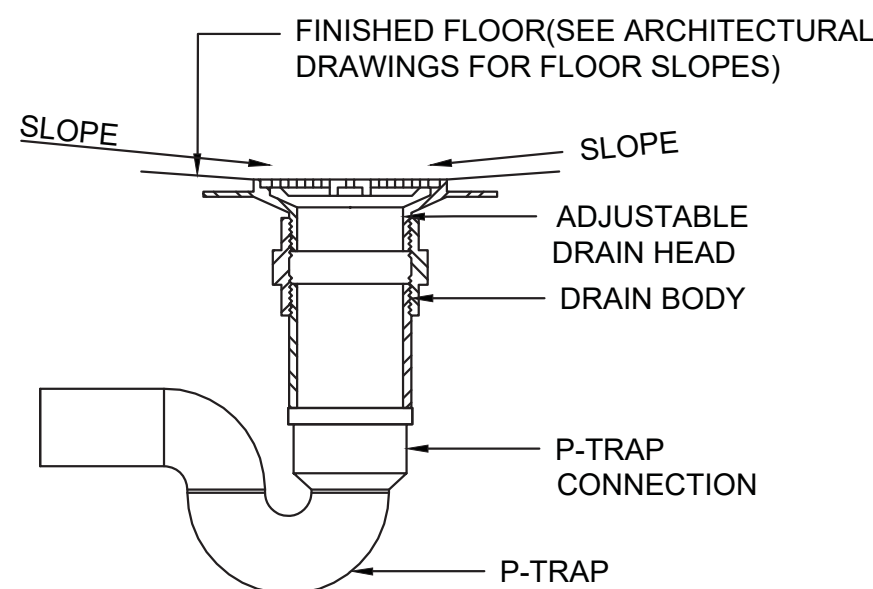


FLOOR DRAIN DETAIL

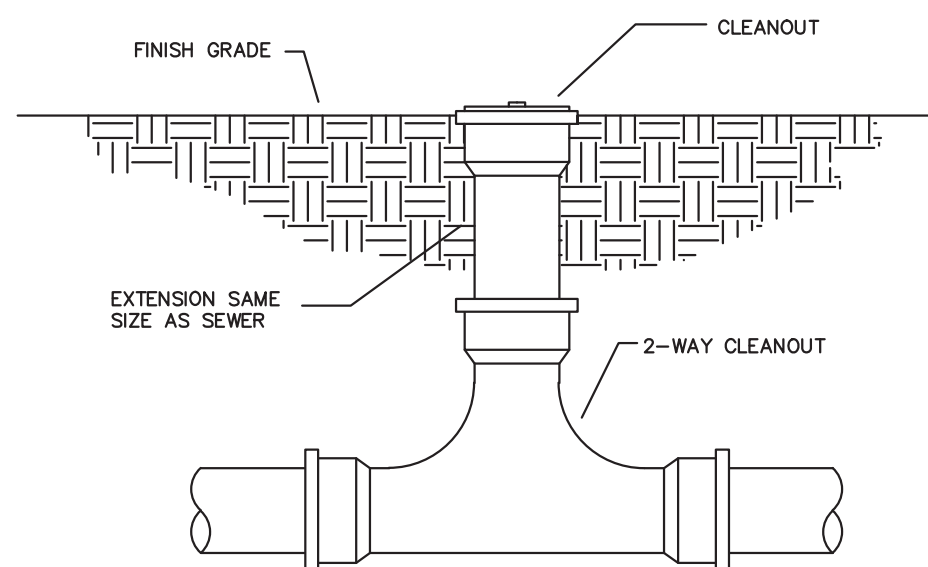


EXTERIOR TWO-WAY CLEANOUT
NOT TO SCALE

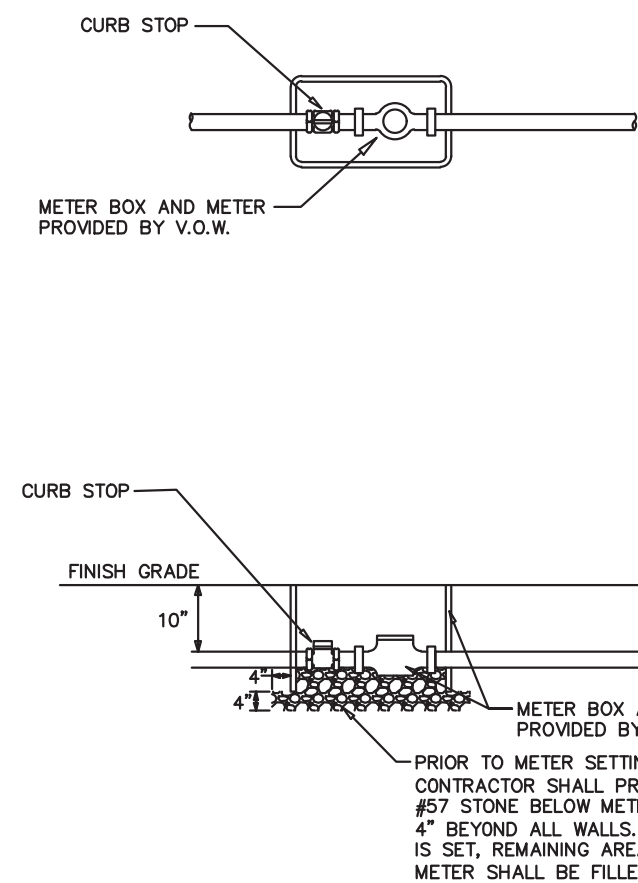

V.O.W. CONSTRUCTION STANDARDS & DETAILS
METER AND METER BOX INSTALLATION

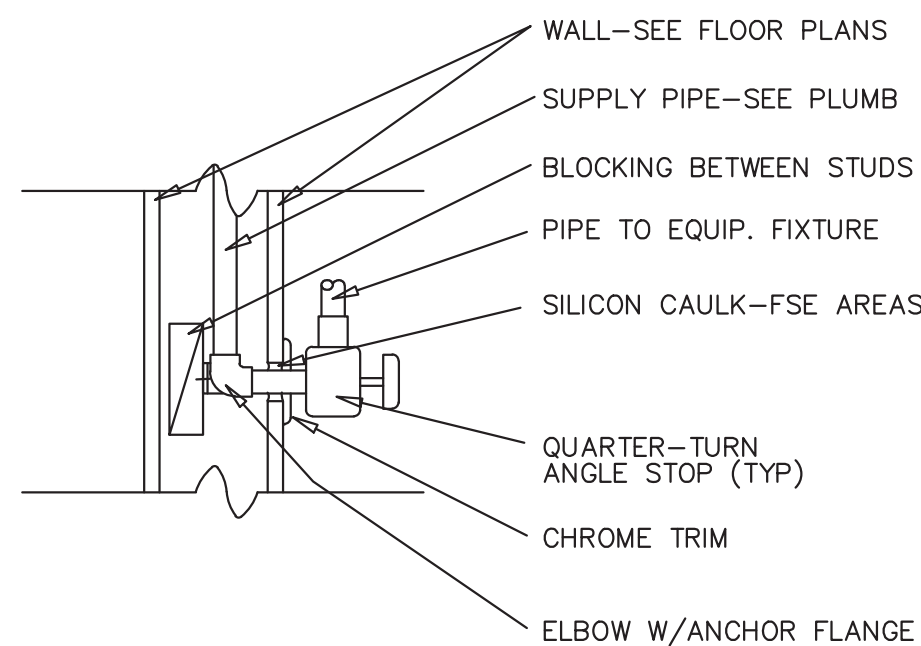

FIXTURE SHUT-OFF VALVE
NOT TO SCALE

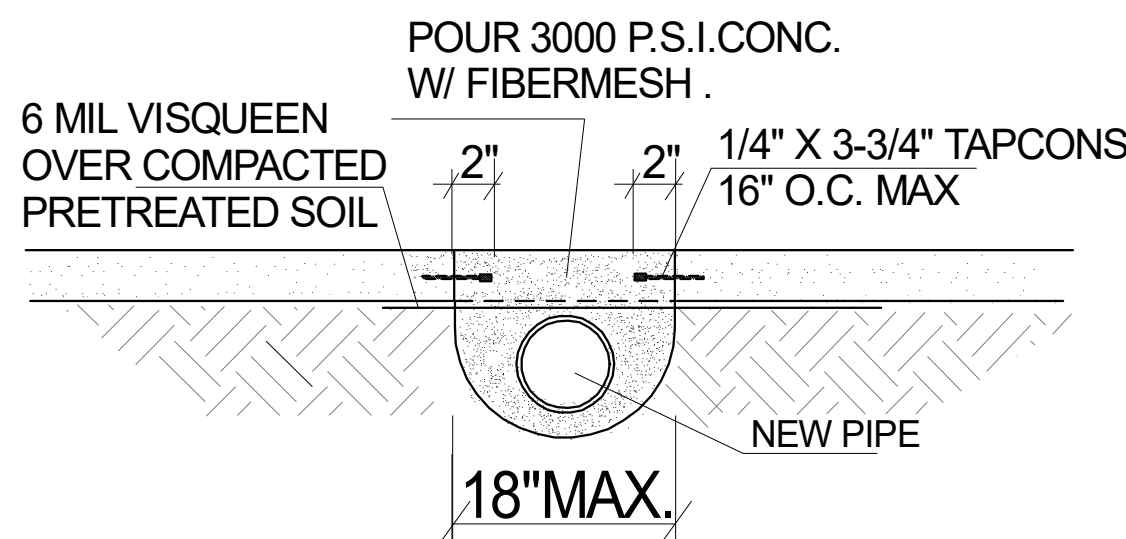

SLAB REPAIR DETAILS

ALL THE DESIGN AND DETAILS ON THIS PLAN ARE THE PROPERTY OF LIGHTNING ENGINEERING AND SHALL NOT BE USED, COPIED OR REPRODUCED WITHOUT THE WRITTEN PERMISSION OF LIGHTNING ENGINEERING.

I HEREBY CERTIFY AS THE BUILDING DESIGN ENGINEER OF RECORD, THAT THE BUILDING DESIGN AS SHOWN ON THESE PLANS AND SPECIFICATIONS IS IN ACCORDANCE WITH THE CERTIFICATION DOES NOT INCLUDE ROOF TRUSS COMPONENTS AND SHALL BE THE RESPONSIBILITY OF THE ARCHITECT OF RECORD. THIS PLAN HAS BEEN PREPARED IN COMPLIANCE WITH THE BUILDING CODE WITH SUPPLEMENTS.

4161 TAMiami TRAIL UNIT 101
PORT CHARLOTTE, FL 33980
TEL: 813-941-8985
FAX: 813-978-8195



NOVA PARKS
46442 PARK CHALET PL, STERLING, VIRGINIA, 20165
MARC O'GRADY DESIGN

PROJECT NAME & ADDRESS:

No.	Description	Date
1		
2		
3		
4		
5		

DRAWN BY: PLC

REVISED BY: JPP

PROJECT NO: 26 173 78

SHEET TITLE:

PLUMBING DETAILS

SHEET NUMBER:

PD-100

PLUMBING PROVISIONS

SECTION 15400 – PLUMBING

1. SCOPE OF WORK

Provide all labor, materials, tools, transportation, and services necessary to complete the plumbing system installation as described in these specifications, as illustrated on the drawings, or as directed by the Architect.

Install all hot- and cold-water systems, including complete connections from the water meter to all plumbing fixtures and any equipment requiring water connections. These systems shall include controls, valves, equipment, devices, and insulation.

Furnish and install all soil, waste, and vent systems, both inside and outside of the building, with sewer connections to the municipal system as indicated on the drawings.

Provide and set all plumbing fixtures, including all required trim, supports, and accessories.

Perform trenching, pipe bedding, backfilling, compaction, and soil treatment as required.

Complete all rough-in and final connections for equipment, fixtures, and service areas as indicated on the drawings, including necessary traps and miscellaneous items. Coordinate all work with the Owner.

Provide all final plumbing connections to heating and air-conditioning equipment, including condensate drains, indirect waste, and gas piping as required.

Meters and Utility Connections:

Water: Coordinate all work with the local water utility. Furnish any labor and materials not provided by the utility and required to connect to the existing line or meter. Install all permanent water supply lines from the point of connection in accordance with local utility requirements. Tap fees are paid by the Owner (if required).

Sewer: Coordinate all work with the local utility. Perform all work and furnish all materials in strict accordance with local requirements. Tap fees are paid by the Owner (if required).

Gas: Coordinate with the local gas utility and provide all labor and materials (not provided by the utility) required to supply a working system for the Owner, including meter and/or regulator. Furnish a complete system from the tapping point to and within the building as shown on the drawings. Tap fees are paid by the Owner.

2. SHOP DRAWINGS

Submit a complete sets of shop drawings in accordance with Section 01300 to the building department at the time of plan review. These drawings shall include all plumbing fixtures, trim, drains, cleanouts, piping, valves, insulation, hangers, supports, equipment, and devices proposed for use.

3. PRODUCT HANDLING

In the event of damage, make all necessary repairs or replacements immediately, to the satisfaction of the Owner.

4. EXAMINATION OF THE SITE

All contractors submitting proposals for this work shall examine the site and note all conditions, including applicable local regulations. Proposals shall reflect all conditions affecting the work under this contract.

5. GUARANTEE

All work performed under this section shall be guaranteed free from defective materials and workmanship.

Upon notification by the Owner or Architect, of any failure in guaranteed equipment within the warranty period, the Contractor shall promptly replace any defective part(s).

6. MATERIALS

A- Soil, Waste, and Vent Piping

Below Floor to 5'-0" Outside Building and Yard Piping: Use A.B.S. or P.V.C. Schedule 40 pipe and fittings if approved by the local authority, or standard-weight coated cast-iron soil pipe with cast-iron/neoprene gasket fittings in compliance with one of the standards listed in Table 702.2 of the International Plumbing Code (IPC). Where piping is installed under driveways or parking areas with superimposed loads, service-weight cast-iron soil pipe with cast-iron/neoprene gasket fittings shall be used.

Above Floor: Use A.B.S. or P.V.C. Schedule 40 (if approved by local authority), or standard-weight coated cast-iron pipe with neoprene rubber gaskets, or hubless cast-iron pipe with neoprene rubber gaskets and stainless-steel clamps (Clamp-All or equal) in compliance with the standards in Table 702.1 of the IPC.

B- Hot and Cold Water Piping

Above Floor or Underground: Use Corzan CPVC Schedule 80 conforming to Tables 605.3 and 605.4 of the IPC, based on intended service. All hot-water distribution pipe and tubing shall have a minimum pressure rating of 100 psi at 180°F. All fittings and connections shall conform to NSF 61 and one of the standards in Table 605.5 of the IPC.

Coordinate with the manufacturer and install expansion loops per their standards. Approved manufacturers include +GF+, IPEX, NIBCO, CEPEX, FIP Durman, Vycor, and Asung.

C- Condensate Drain Piping

Condensate drain piping shall be Corzan CPVC Schedule 80 from HVAC units and other equipment unless otherwise noted.

D- Indirect Waste Piping

Unless otherwise indicated, provide Schedule 40 piping. Slope drainage pipe in accordance with IPC Table 704.1:

2-1/2" or smaller: 1/4" per foot

3" to 6": 1/8" per foot

8" or larger: 1/16" per foot

E. Natural Gas Piping

Provide gas piping, including tap and service. Coordinate meter location with the local authority.

Underground gas piping shall be Schedule 40 black steel pipe with long-radius steel welding fittings, protected with Tranflex wrapping tape (or equivalent) per manufacturer's recommendations.

Gas piping above ground shall be Schedule 40 black steel with 125 lb. black malleable iron screwed fittings, supported at intervals not exceeding 8'-0" and at each change in direction.

Gas pipe joint compound shall comply with NFPA 54 and local codes, suitable for natural gas service.

Provide moisture traps on each drop to the water heater and any kitchen equipment.

Support piping in accordance with Sections 407 and 415 of the International Building Code – Fuel Gas (IBC).

F. Storm Drain Leaders

Storm drain piping shall be the same materials as for soil, waste, and vent piping, per above paragraphs.

G. Insulation

Insulate all water pipes, rain leaders, etc., to prevent heat loss and condensation (when applicable).

Piping in unconditioned spaces shall be protected against freezing (when applicable).

Use minimum 1" thick foam insulation with a conductivity not exceeding 0.28 BTU per inch/hr/ft²/F (per IECC, Section C404.4 and IPC, Section 607.5).

Insulation shall be Armaflex by Armstrong or approved equal.

Seal all butt ends and longitudinal joints with rubber-based adhesive.

PLUMBING PROVISIONS CONTINUE

7. FIXTURES

A. Refer to drawings for fixture specifications.

8. FLASHINGS

A. Provide watertight flashing for all piping and vents passing through the roof, using six-pound-per-square-foot lead sleeves. The sleeve base shall extend at least 12 inches in each direction beyond the outside diameter of the pipe.

B. Turn the sleeve down a minimum of 1-1/2 inches into the top of the vent pipe, fitting the lead snugly inside the pipe.

C. Gas vent caps shall be vandal-proof and flashed similarly.

D. Confirm approved flashing materials and methods with the Roofing Contractor.

9. CLEANOUTS

A. Refer to drawings for cleanouts specifications.

10. EQUIPMENT

A. Water Heater

Furnish and install the water heater(s) as indicated on the drawings (gas or electric).

Provide all temperature and safety controls, including ASME- and ANSI Z21.22-rated temperature and pressure relief valve, gas pressure regulator (if required), drain valve, and expansion tank, as applicable.

Provide water, gas, and relief line connections with shutoff valves and dielectric unions in water and gas lines.

B. Valves, Cocks, and Faucets

Unless noted otherwise, all valves shall be rated for a minimum of 160 psi working pressure and shall comply with IPC Section 606. Valves shall be compatible with the piping material and have rising stems with back seats for repacking under pressure (where applicable). All materials shall conform to lead content standards of Section 605.7, IPC. Acceptable manufacturers include Stockham, Walworth, Lunkenheimer, Scott, Hammond, Crane, or Watts (or similar approved manufacture).

Gate valves shall be compatible with the piping system, and any supplying drinking water must meet NSF 61.

Provide chrome-plated angle stop valves with soft annealed chrome-plated copper supply tubes and escutcheons for lavatories, tank-type water closets, sinks, and water closets.

Gas cocks: See drawings for all equipment requiring gas shutoff cocks.

Exterior hose bibbs/valves shall be non-freeze type, with supply shutoff valves if noted.

C. Bathtub

Temperature limiting devices shall be provided for bathtub as per P2713.3

11. EXECUTION

A. Piping

Conceal all piping unless otherwise shown on the drawings.

Install valves, traps, cleanouts, and other apparatus in easily accessible locations.

Slope soil and waste lines in accordance with IPC Table 704.1: 1/4" per foot for pipes 2-1/2" and under; 1/8" per foot for pipes 3" to 6", unless otherwise indicated or required by local codes.

Separate hot and cold water lines by at least 6" when run in parallel.

Run all water lines overhead and down partition walls unless no wall is available. In such cases, run lines under the slab to the point of termination.

B. Hangers and Supports

Support gas piping at intervals not exceeding 8'-0" and at each change of direction with steel pipe hangers (e.g., Grinnell or Fee & Mason). Attachment to structure shall comply with IBC Sections 407 and 415.

Hanger rods shall be standard steel bolt stock, 3/8" minimum diameter.

All underground piping shall be firmly bedded, with bell holes provided at each bell. Install piping in a graded trench, and excavate/backfill per the requirements in these specifications.

Indoor Finishes

Hangers and clamps supporting bare copper piping shall be coated with copper-colored epoxy paint (B-Line Dura-Copper®). Where necessary, add an additional PVC coating.

Hangers for other pipe types shall be zinc-plated (ASTM B633) or have an electro-deposited green epoxy finish (B-Line Dura-Green®).

Strut channels shall be pre-galvanized (ASTM A653 SS Grade 33 G90) or have an electro-deposited green epoxy finish (B-Line Dura-Green®).

Outdoor/Corrosive Environments

Hangers and strut for outdoor applications shall be hot-dip galvanized post-fabrication (ASTM A123). All associated hardware shall be hot-dip galvanized or stainless steel; zinc plating is not acceptable outdoors or in corrosive areas.

In corrosive areas, hangers and strut shall be Type 304 [316] stainless steel with stainless hardware.

C. Plumbing Fixtures

Furnish and install all plumbing fixtures complete with necessary fittings, trim, and accessories.

D. Tests

The permit holder shall conduct all applicable tests prescribed in Sections 312.2 through 312.10 of the IPC to confirm code compliance.

All plumbing system piping shall be tested with water or (for non-plastic piping) by air.

E. Cleaning and Protection

Remove all debris and leftover materials for which this Contractor is responsible. Clean all fixtures and equipment, and repair any blemishes to the finish. Replace any fixtures damaged due to improper protection during installation.

Flush out new piping with chlorine or HTH solution to remove foreign matter and sanitize, as required by local authorities and IPC Section 610.

F. Maintenance

Clean drain lines prior to project turnover.

GENERAL NOTES

- It is the responsibility of the Plumbing Contractor to review both the plans and written specifications to understand the full scope of work. Coordinate with the Owner's representative for any requirements not specified herein but considered part of the contract. Visit the site to assess existing conditions.
- Equipment in the kitchen requiring filtered, purified, or distilled water shall be identified by the Owner. Filters or R.O. system specifications shall be provided by the Owner. The contractor shall review these specifications and coordinate with the Owner to understand all system requirements and any additional locations needing service.
- Lack of thorough understanding of existing conditions shall not excuse errors or omissions nor justify additional costs.
- The Contractor shall field-measure and verify all dimensions and conditions before starting work.
- All plumbing and gas installations shall conform to the latest editions of the following:

Virginia Building Code – Residential, 2021

Virginia Building Code – Building, 2021

Virginia Building Code – Existing Building, 2021

Virginia Building Code – Mechanical, 2021

Virginia Building Code – Plumbing, 2021

Virginia Building Code – Energy Conservation, 2021

Virginia Building Code – Fuel Gas, 2021

Virginia Fire Prevention Code, 2021

NFPA (latest applicable editions)

ASHRAE Standard 62.1
- Piping layouts on the drawings are diagrammatic, showing general arrangement, size, and capacity only. All offsets are not necessarily shown. The Contractor shall furnish offsets, valves, vents, and fittings to avoid conflicts with other trades and structural/architectural elements as needed.
- The Plumbing Contractor's scope includes all work indicated on these drawings.
- Coordinate all piping routes with other trades before installation.
- Verify invert elevations and the exact locations of existing sewers before installing new sewer connections.
- Install isolation valves at each domestic water branch takeoff and unions at each equipment, fixture, or appliance service point per IPC Sections 606.1 and 606.2.
- Maintain proper separation between sewer pipe and water service lines in accordance with IPC requirements and referenced tables.
- Provide a drain pan with a proper drainage system under piping/ductwork located above any electrical panel.
- Contractor to provide recirculation line if distance from water heater to furthest plumbing fixture exceeds 50'.

PLUMBING SYMBOLS LEGEND

ABBREVIATIONS:	
AFF/AFG	ABOVE FINISHED FLOOR/GRADE
AHJ	AUTHORITY HAVING JURISDICTION
AS	ANGLE STOP
BFP	BACKFLOW PREVENTER
CO	CLEANOUT
ETR	EXISTING TO REMAIN
FPC	FIRE PROTECTION CONTRACTOR
FFCO/FGCO	FLUSH FLOOR/GRADE CLEANOUT
KEC	KITCHEN EQUIPMENT CONTRACTOR
GC	GENERAL CONTRACTOR
IW	INDIRECT WASTE
OC	ON CENTERS
MC	MECHANICAL CONTRACTOR
NFPA	NATIONAL FIRE PROTECTION ASSOCIATION
PC	PLUMBING CONTRACTOR
RI	ROUGH-IN
TYP	TYPICAL
VTR	VENT THRU ROOF
WCO	WALL CLEANOUT
LINETYPES:	
—————	COLD WATER (CW)
—————	HOT WATER (HW)
—————	HOT WATER RETURN (HWR)
————G————	GAS LINE (G)
—————	PLUMBING VENT (V)
-----	PLUMBING VENT (V) - BELOW SLAB/GRADE
—————	SANITARY WASTE (SAN) - BELOW SLAB/GRADE
—————D————	CONDENSATE (D)
GENERAL REFERENCES/NOTATIONS:	
	CONNECT TO EXISTING
	KEY NOTE
XXX	PLUMBING FIXTURE/EQUIPMENT TAG
	DETAIL OR SECTION REFERENCE
PIPE SYMBOLS:	
	PIPE TURNING UP/DOWN
	TEE TURNING UP/DOWN
	SHUT-OFF VALVE (BALL TYPE)
	PRESSURE REGULATOR
	END CAP

ALL THE DESIGN AND DETAILS ON THIS PLAN ARE THE PROPERTY OF LIGHTNING ENGINEERING. IT IS NOT TO BE USED, COPIED OR REPRODUCED WITHOUT THE WRITTEN PERMISSION OF LIGHTNING ENGINEERING.

I HEREBY CERTIFY AS THE BUILDING DESIGN ENGINEER OF RECORD, THAT THE BUILDING DESIGN AS SHOWN ON THESE PLANS AND SPECIFICATIONS IS THE DESIGN OF THE ENGINEER. I AM A LICENSED PROFESSIONAL ENGINEER IN THE STATE OF VIRGINIA. MY LICENSE NUMBER IS 1010000000. THIS CERTIFICATION DOES NOT INCLUDE ROOF TRUSS COMPONENTS OR STRUCTURAL STEEL DESIGN. I AM NOT PROVIDING ANY OF THESE SERVICES. THIS PLAN HAS BEEN PREPARED IN COMPLIANCE WITH THE BUILDING CODE WITH SUPPLEMENTS.

4161 TAMiami TRAIL UNIT 101
PORT CHARLOTTE, FL 33980
P 813-978-8195
FAX 813-978-8195



NOVA PARKS

46442 PARK CHALET PL, STERLING, VIRGINIA, 20165

MARC O'GRADY DESIGN

No.	Description	Date
Δ		
Δ		
Δ		
Δ		
Δ		

DRAWN BY: PLC

REVISED BY: JPP

PROJECT NO: 26 173 78

SHEET TITLE:

PLUMBING
DETAILS

SHEET NUMBER:
PD-101